AS-BUILT DOCUMENTATION

Latham Pool Products

Zephyrhills, FL 33540



TEMPLY COMPANY CAMBRIDGE CLARK ESTATES CLOLONY COMPANY RUANN ESTATES SPANISH TRAILS VILLAGE COLONY ALE RO TION INC Sonnys BBQ Zephyrhills North NEVANS ACREAGE ESTATE FOREST LAKE ESTATES MOBILE HOME PARK MYNHOMES N HILLS TATES North AR MOBILE HOME NOBILE HOME PARK CO-OP HAZEL HEIGHTS GE THATES HEATHER WOOD ODD CLITY OF HAZEL HEIGHTS GE THATES HEATHER WOOD HAZEL HEIGHTS GE THATES HEATHER WOOD AND CLITY OF THATEL HEIGHTS GE THATES THATES NORTH AR THATEL HEIGHTS THATES THATES


DRAWING INDEX

SYMBOLS LEGEND

FLOOR PLAN

COVER SHEET | DRAWING INDEX



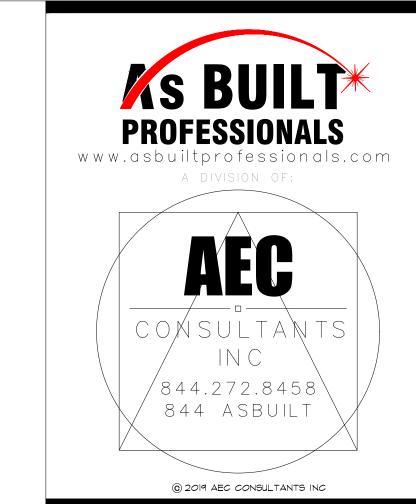

ARCHITECTURAL AS BUILT Latham Pool Products

1 100% SUBMISSION SEE COVER SHEET
0. ISSUES | REVISIONS DATE

COVER
SHEET

PROJECT MANAGER

PROJECT DIRECTOR

PROJECT NUMBER

100% SUBMITTAL

SEPTEMBER 19, 2019

FIRE EXTINGUISHER

FIRE PULL

FIRE ALARM (HORN/SRTOBE)

SMOKE DETECTOR

SMOKE ALARM SPEAKER

SPRINKLER HEAD CEILING MOUNT

SPRINKLER HEAD WALL MOUNT

THERMOSTAT

FLOOR DRAIN

 $\bigvee A L \bigvee \equiv$

HOSE BIB

WATER SUPPLY

SUSPENDED GAS HEATER

BOLLARD

11-4-11/16 SPOT ELEVATION

PHOTO DOCUMENTATION LEGEND

INDICATES LOCATION OF CAMERA

- INDICATES DIRECTION OF CAMERA LENS AND CORRESPONDING PHOTO / VIDEO

TYPES OF DOCUMENTATION

GROUND BASED GROUND BASED 360° SHPERICAL AERIAL BASED

PROJECT MANAGER PROJECT DIRECTOR PROJECT NUMBER 012318-1

NO SCALE

SHEET NUMBER

CONSULTANTS ⁷844.272.8458 844 ASBUILT @ 2019 AEC CONSULTANTS INC

PROFESSIONALS www.asbuiltprofessionals.com

3 ер T ARC

01 100% SUBMISSION SEE COVER SHEET

NO. ISSUES | REVISIONS

SHEET TITLE

SCALE

SL

DATA OUTLET TELEPHONE JACK

ELECTRIC SWITCH

CABLE TELEVISION OUTLET

DUPLEX RECEPTACLE

SPECIAL PURPOSE CONNECTION OR OUTLET

QUADRUPLEX RECEPTACLE

OUTLET

FLOOR DUPLEX RECEPTACLE OUTLET

ELECTRIC PANEL

BUTTON SWITCH

DISCONNECT

SMITCH

GROUND/FLOOR LIGHT

KEY PAD



OR VANITY LIGHT

EMERGENCY

EXIT LIGHT W/ SIGN


TRACK LIGHT

LIGHTED STAIR STAIR SIGN


X

FLOOD LIGHT

 PHOTO CELL



CEILING FAN

 

CEILING FAN W/ LIGHT KIT

CEILING HEIGHT AND TRIM 7-2-6 CEILING HEIGHT AND TRITT 7'-2" ABOVE FLOOR BELOW WITH 6" CROWN MOULDING. NOTE: ALL CEILINGS NOT LABELED ARE PLASTER. CEILINGS SHOWN WITH A GRID

ARE LAY IN ACOUSTICAL TILE ..

JUNCTION BOX

SPEAKER

EXHAUST VENT

LIGHT FIXTURE

CEILING MOUNTED

CEILING MOUNTED

PENDANT LIGHT

LAY-IN FIXTURE

FIXTURE 2 BULB

4 BULB

HANGING

CAMERA

MOTION DET.

SUPPLY VENT

SUPPLY VENT

RETURN VENT

RETURN VENT

INDIVIDUAL FLUOR.

INDIVIDUAL FLUOR.

INDIVIDUAL FLUOR.

FLUSH MOUNT FIXTURE


DIRECTIONAL LIGHT

RECESSED CAN LIGHT

EYEBALL OR SMALL CAN LIGHT

DIRECTION OF DETAIL

IDENTIFYING DETAIL NAME -SHEET NUMBER DETAIL IS LOCATED ON

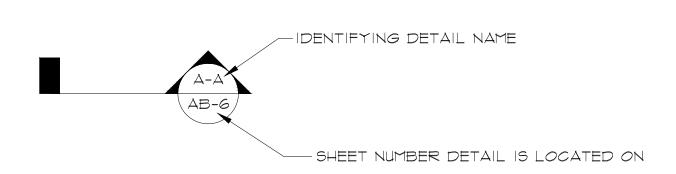



012318-1

3/32"=1'-0"

AB-1





OFFICE - MAREHOUSE FLOOR PLAN 25,115 SQ. FT.