

AS-BUILT DOCUMENTATION

Mountain Retreat Chattanooga TN, 37419



100% SUBMITTAL

DRAWING INDEX

- C-1 COVER SHEET | DRAWING INDEX
- SL SYMBOLS LEGEND
- AB-1 BASEMENT FLOOR PLAN
- AB-2 FIRST FLOOR PLAN
- AB-3 SECOND FLOOR PLAN
- AB-4 FRONT AND REAR ELEVATION
- AB-5 SIDE ELEVATIONS
- AB-6 EXTERIOR PHOTO KEY MAP



VICINITY MAP
NTS

AREA DATA	
LIVING BASEMENT	596 S.F. ±
LIVING FIRST FLOOR	2,784 S.F. ±
LIVING SECOND FLOOR	2,180 S.F. ±
SECOND FLOOR STORAGE	314 S.F. ±
SCREEN ROOM	236 S.F. ±
DECKS	863 S.F. ±
GARAGE	651 S.F. ±
ENTRY	195 S.F. ±
TOTAL LIVING	5,560 S.F. ±
GRAND TOTAL	7,879 S.F. ±

AS BUILT

PROFESSIONALS

www.asbuiltprofessionals.com

A DIVISION OF:

AEC

CONSULTANTS INC

844.272.8458

844 AS BUILT

© 2017 AEC CONSULTANTS INC

ARCHITECTURAL AS BUILT
Chattanooga TN, 37419

 
01	100% SUBMISSION	
NO.	ISSUES REVISIONS	DATE
SHEET TITLE		
COVER SHEET		
HL	PROJECT MANAGER	
HL	PROJECT DIRECTOR	
012317-1	PROJECT NUMBER	
	SCALE	
CL	DRAWN BY	
SHEET NUMBER		

 
C-1

 
SYMBOLS LEGEND

 
RCP

- 

 
EXHAUST VENT
- 

 
CEILING MOUNTED LIGHT FIXTURE
- 

 
CEILING MOUNTED DIRECTIONAL LIGHT
- 

RECESSED CAN LIGHT
- 

EYEBALL OR SMALL CAN LIGHT
- 

PENDANT LIGHT
- 

 
INDIVIDUAL FLUOR. LAY-IN FIXTURE 4 BULB
- 

 
INDIVIDUAL FLUOR. HANGING FIXTURE 2 BULB
- 

 
INDIVIDUAL FLUOR. FLUSH MOUNT FIXTURE 4 BULB
- 

 
CAMERA
- 

MOTION DET.
- 

 
SUPPLY VENT
- 

 
SUPPLY VENT
- 

RETURN VENT
- 

 
RETURN VENT
- 

 
SPEAKER

 
- 

TRACK LIGHT OR VANITY LIGHT
- 

WALL-MOUNTED LIGHT FIXTURE
- 

EMERGENCY EXIT SIGN
- 

EMERGENCY EXIT LIGHT
- 

EMERGENCY EXIT LIGHT W/ SIGN
- 

LIGHTED STAIR SIGN
- 

 
 
FLOOD LIGHT
- 

PHOTO CELL
- 

CEILING FAN
- 

CEILING FAN W/ LIGHT KIT
- 7-2-6

CEILING HEIGHT AND TRIM 7'-2" ABOVE FLOOR BELOW WITH 6" CROWN MOULDING. NOTE: ALL CEILINGS NOT LABELED ARE PLASTER. CEILINGS SHOWN WITH A GRID ARE LAY IN ACOUSTICAL TILE..
- 

 
JUNCTION BOX

 
ELECTRIC

- 

DATA OUTLET
- 

 
TELEPHONE JACK
- 

ELECTRIC SWITCH
- 

 
CABLE TELEVISION OUTLET
- 

DUPLEX RECEPTACLE OUTLET
- 

 
SPECIAL PURPOSE CONNECTION OR OUTLET
- 

 
QUADRUPLEX RECEPTACLE OUTLET
- 

FLOOR DUPLEX RECEPTACLE OUTLET
- 

ELECTRIC PANEL
- 

ELECTRIC METER
- 

BUTTON SWITCH
- 

DISCONNECT SWITCH
- 

GROUND/FLOOR LIGHT
- 

KEY PAD

FIRE PROTECTION

- 

FIRE EXTINGUISHER
- 

FIRE PULL
- 

FIRE ALARM (HORN/SRTOBE)
- 

SMOKE DETECTOR
- 

SMOKE ALARM SPEAKER
- 

SPRINKLER HEAD CEILING MOUNT
- 

SPRINKLER HEAD WALL MOUNT

MEP

- 

THERMOSTAT
- 

FLOOR DRAIN
- 

VALVE
- 

 
HOSE BIB
- 

WATER SUPPLY
- 

SUSPENDED GAS HEATER

MISC

- 

BOLLARD
- 

SPOT ELEVATION

7-2-6

CEILING HEIGHT AND TRIM 7'-2" ABOVE FLOOR BELOW WITH 6" CROWN MOULDING. NOTE: ALL CEILINGS NOT LABELED ARE PLASTER. CEILINGS SHOWN WITH A GRID ARE LAY IN ACOUSTICAL TILE..

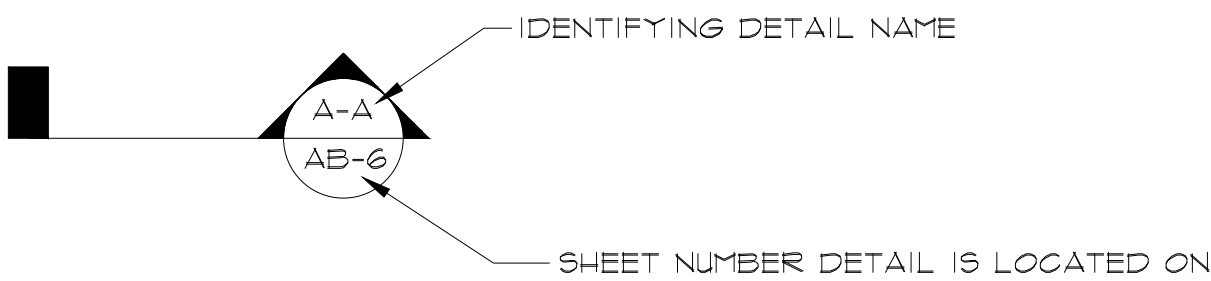
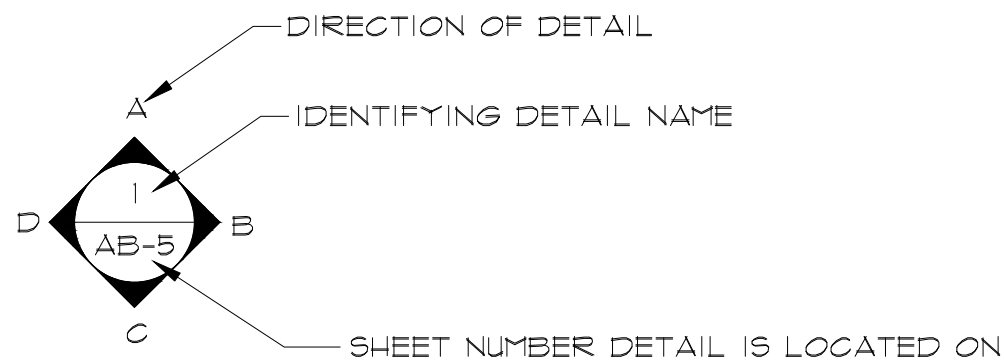


 
PHOTO DOCUMENTATION LEGEND

- 

INDICATES LOCATION OF CAMERA
- 

 
INDICATES DIRECTION OF CAMERA LENS AND CORRESPONDING PHOTO / VIDEO NUMBER

TYPES OF DOCUMENTATION

- 

GROUND BASED PHOTO
- 

GROUND BASED VIDEO
- 

360° SPHERICAL PHOTO
- 

AERIAL BASED PHOTO
- 

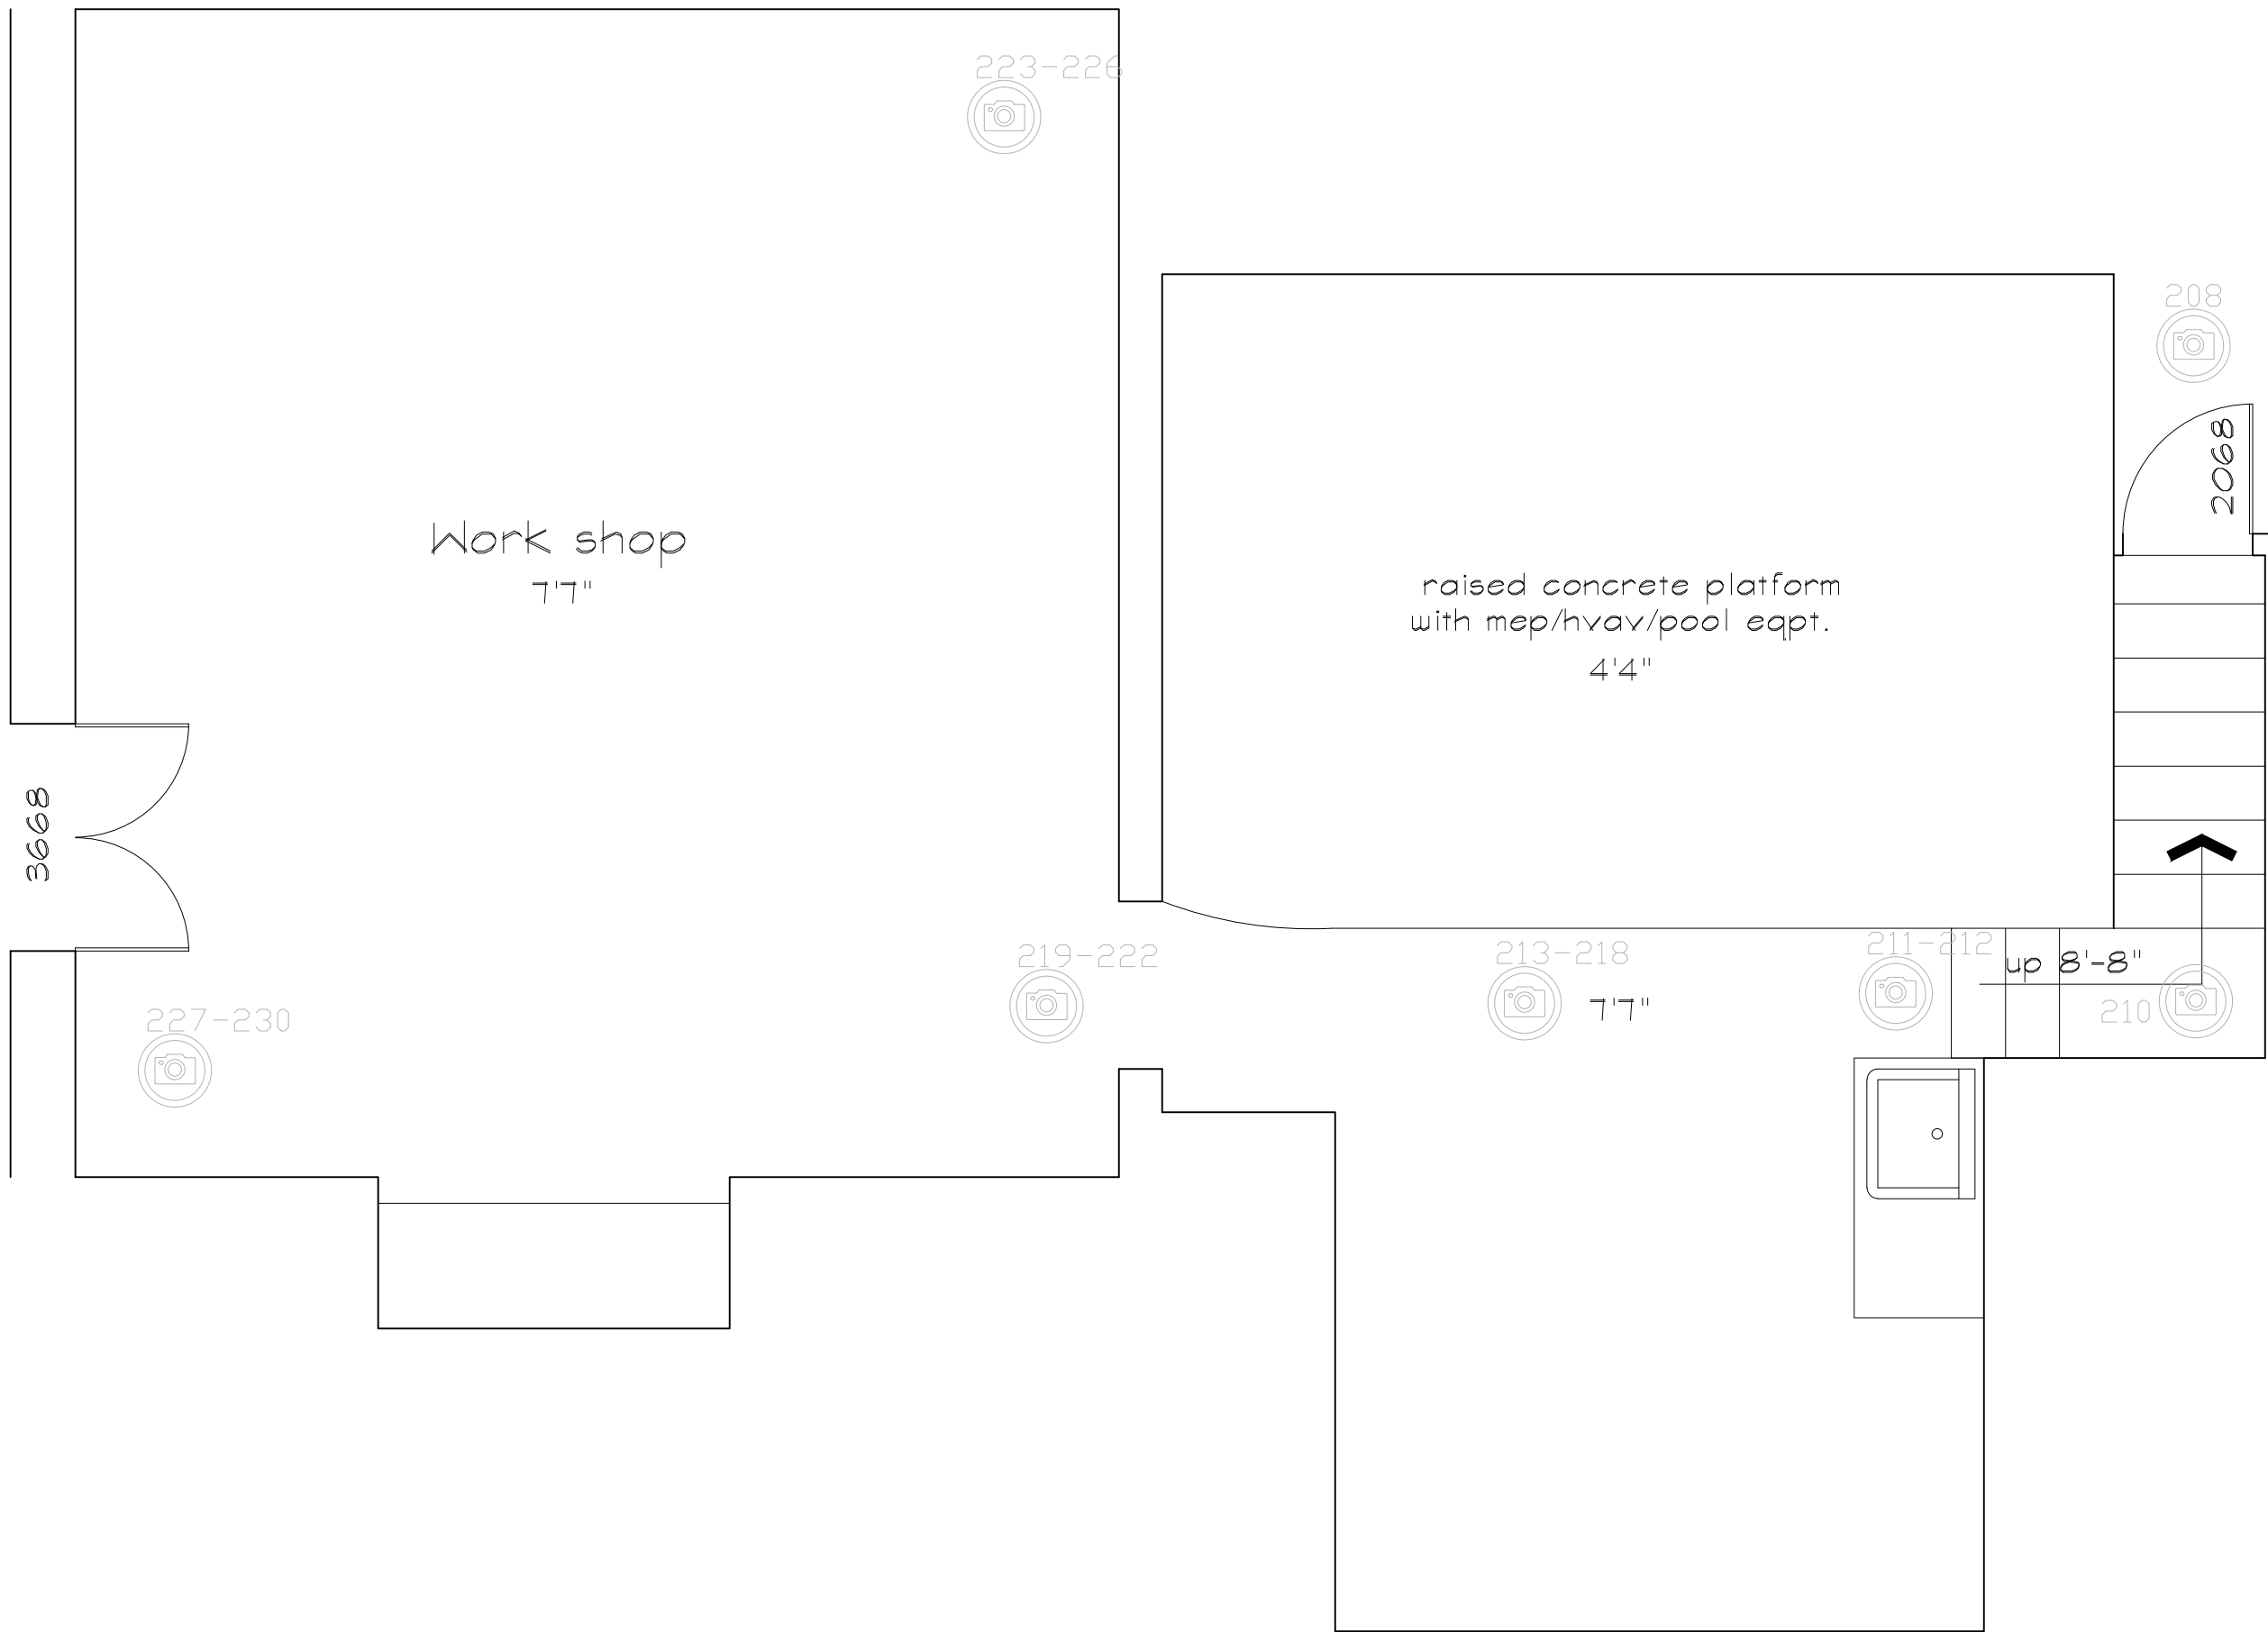
AERIAL BASED VIDEO

ARCHITECTURAL AS BUILT

Chattanooga TN, 37419

01	100% SUBMISSION	
NO.	ISSUES REVISIONS	DATE
		SHEET TITLE
HL	PROJECT MANAGER	
HL	PROJECT DIRECTOR	
012317-1	PROJECT NUMBER	
NOT TO SCALE		SCALE
CL	DRAWN BY	
		SHEET NUMBER

SL



BASEMENT FLOOR PLAN

As BUILT

PROFESSIONALS

www.asbuiltprofessionals.com

A DIVISION OF:

AEC

CONSULTANTS INC

844.272.8458

844 AS BUILT

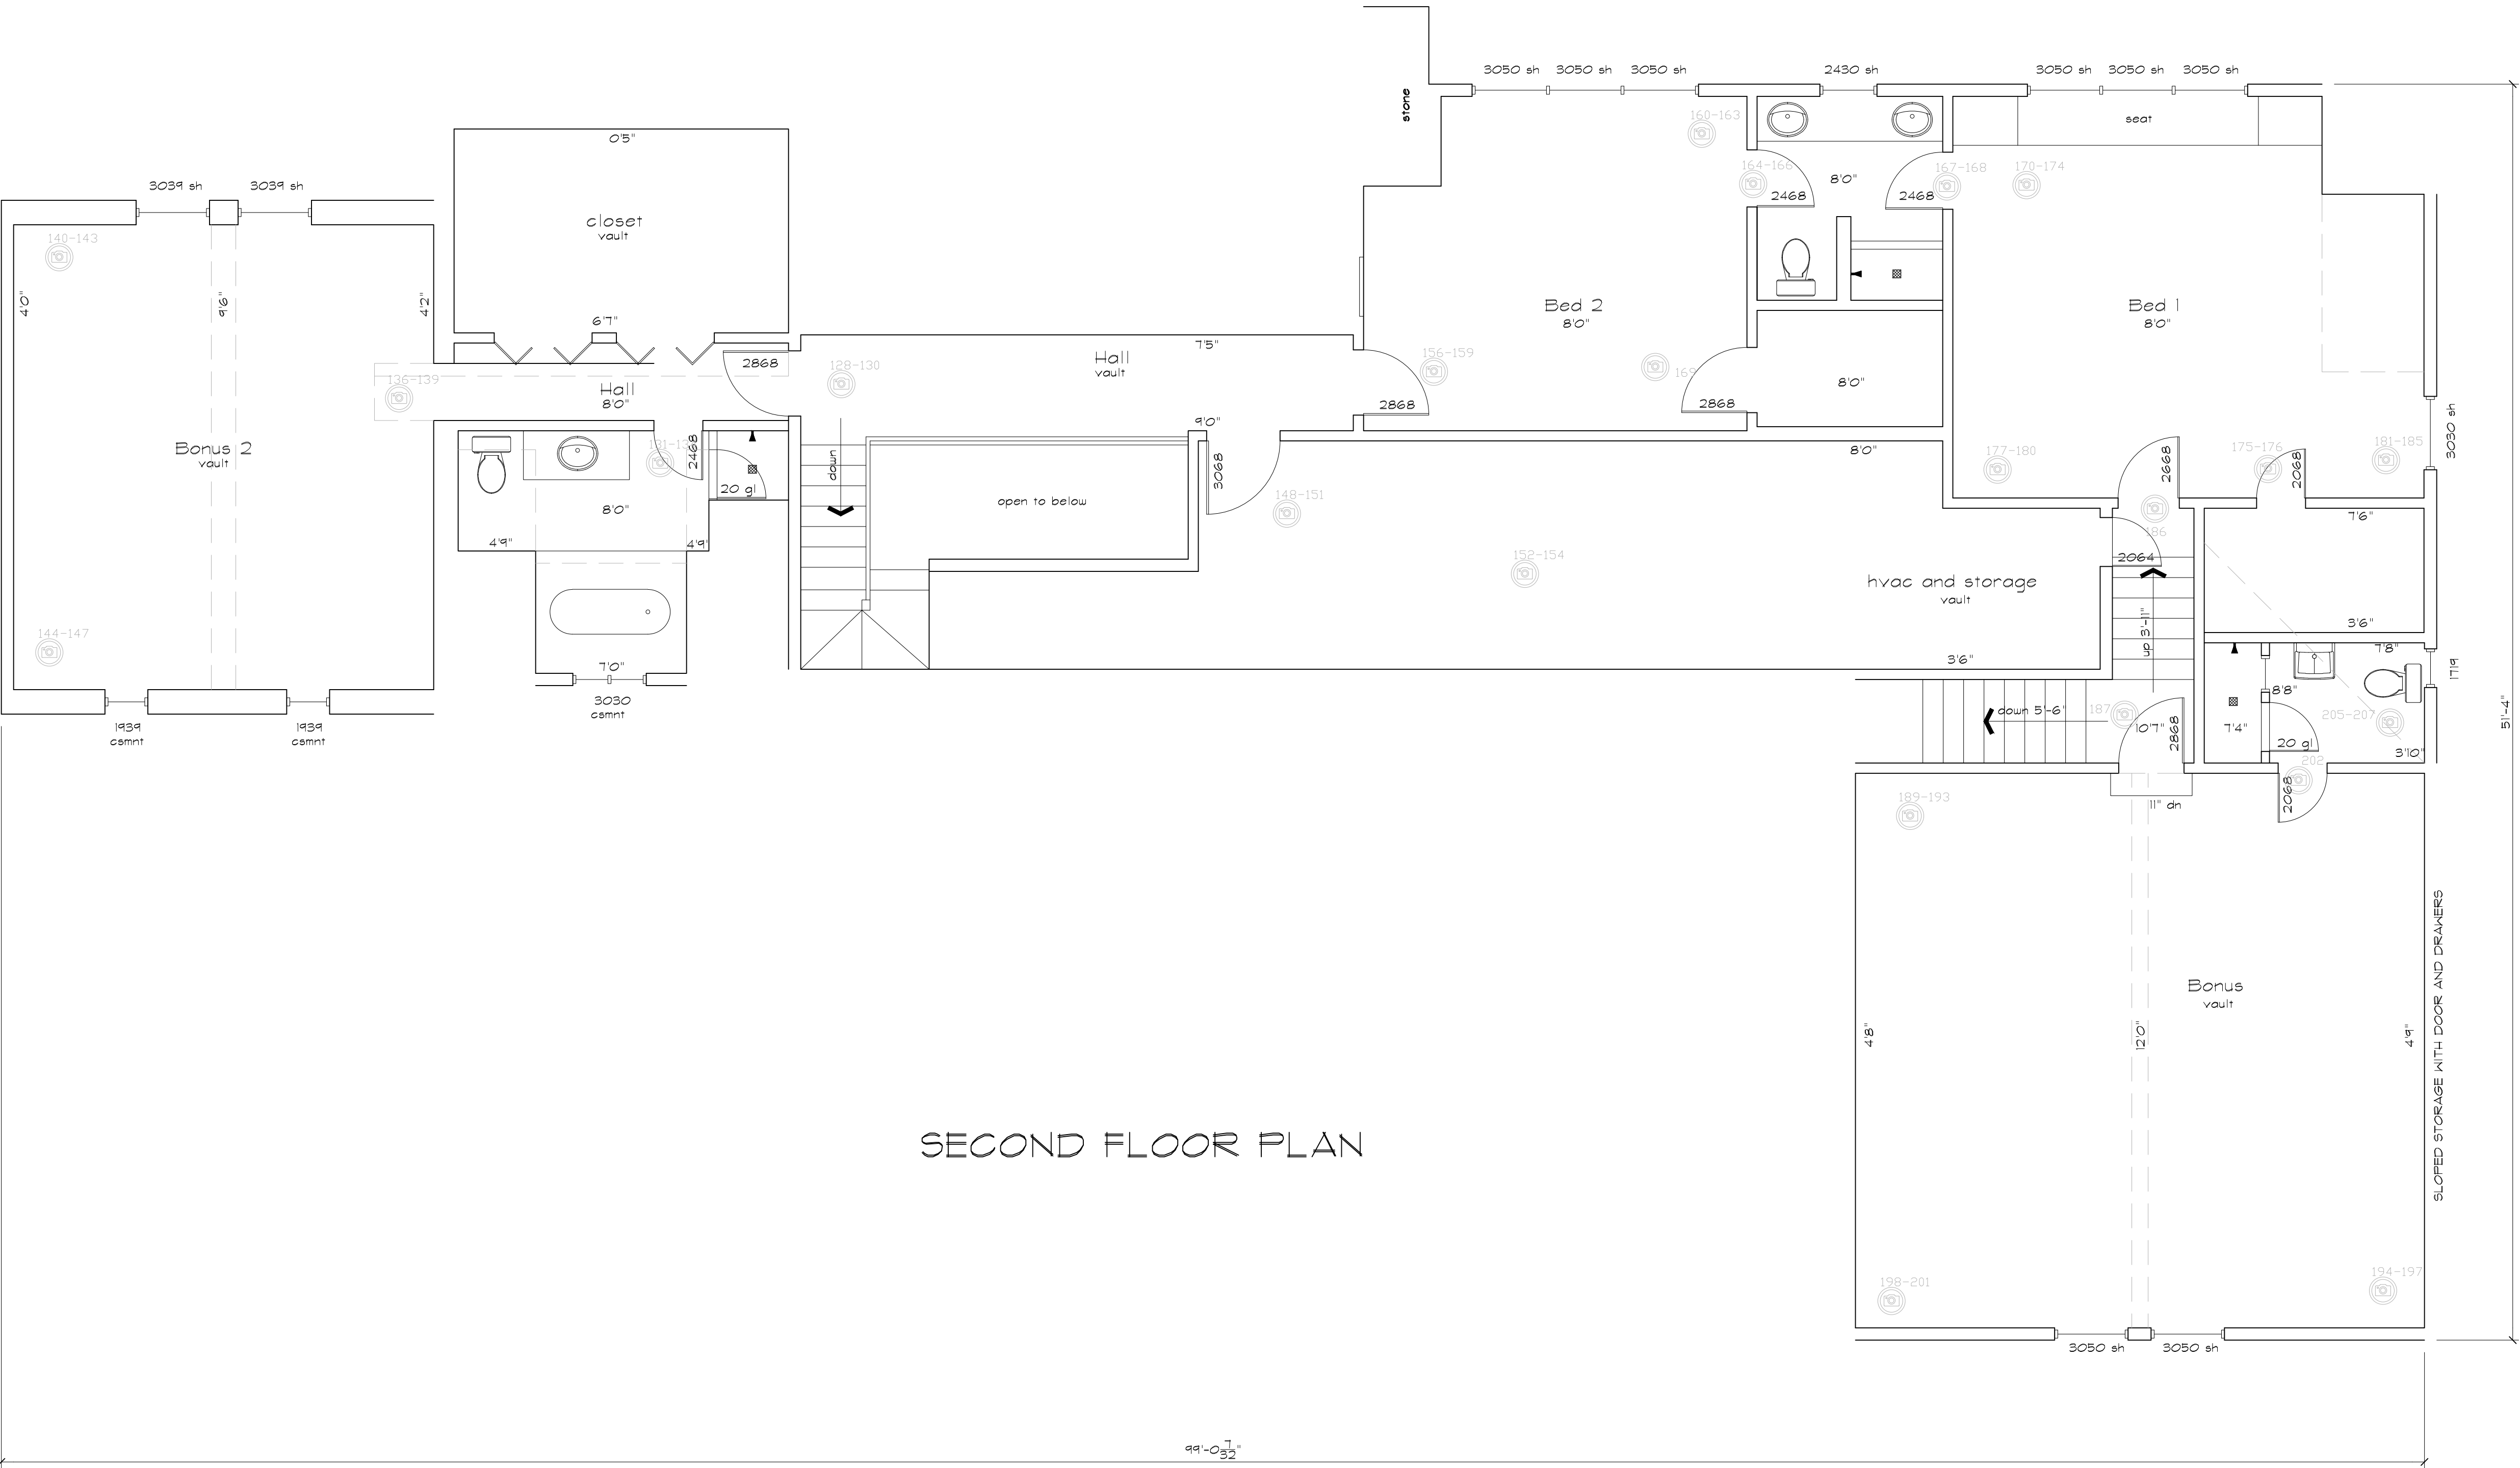
© 2011 AEC CONSULTANTS INC

ARCHITECTURAL AS BUILT

Chattanooga TN, 37419

01	100% SUBMISSION	
NO.	ISSUES REVISIONS	DATE
SHEET TITLE		
HL		PROJECT MANAGER
HL		PROJECT DIRECTOR
012317-1		PROJECT NUMBER
3/8"=1'-0"		SCALE
CL		DRAWN BY
SHEET NUMBER		

AB-1



SECOND FLOOR PLAN

As BUILT

PROFESSIONALS

www.asbuiltprofessionals.com

A DIVISION OF:

AEC

CONSULTANTS INC

844.272.8458

844 AS BUILT

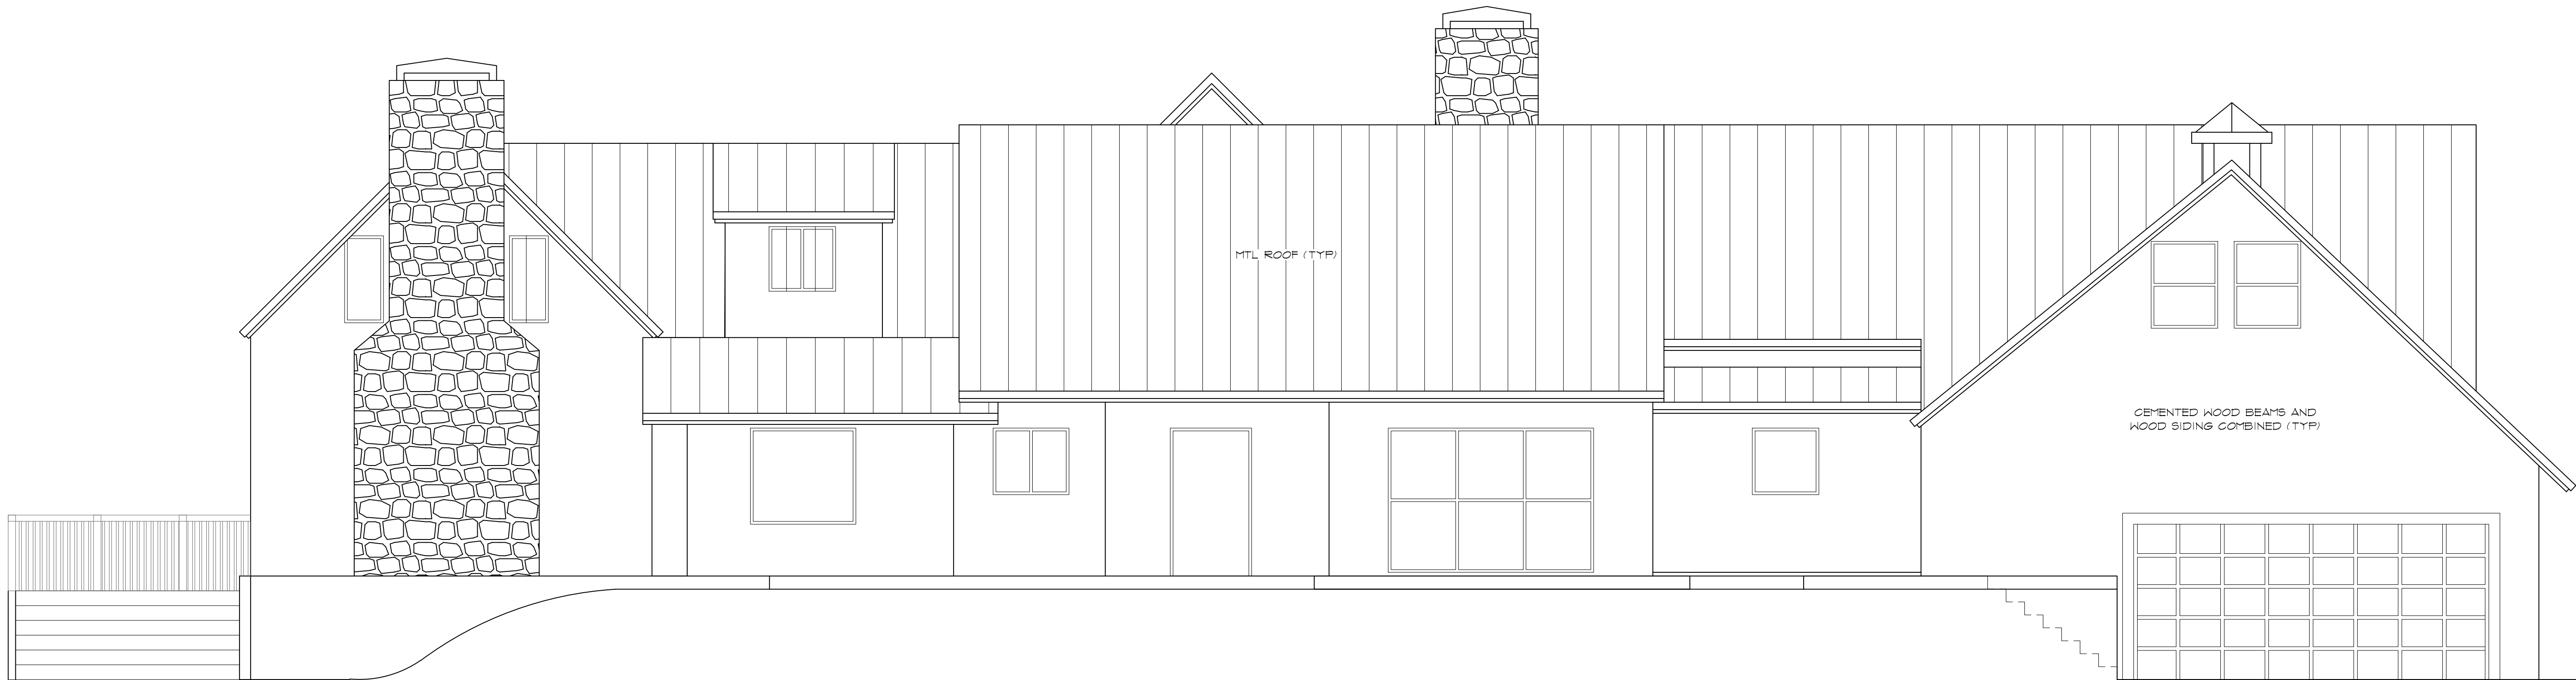
© 2011 AEC CONSULTANTS INC

ARCHITECTURAL AS BUILT

Chattanooga TN, 37419

01	100% SUBMISSION	
NO.	ISSUES REVISIONS	DATE
SHEET TITLE		
HL		PROJECT MANAGER
HL		PROJECT DIRECTOR
012317-1		PROJECT NUMBER
1/4"=1'-0"		SCALE
CL		DRAWN BY
SHEET NUMBER		

AB-3



FRONT ELEVATION



REAR ELEVATION

As BUILT

PROFESSIONALS

www.asbuiltprofessionals.com

A DIVISION OF:

AEC

CONSULTANTS INC

844.272.8458

844 AS BUILT

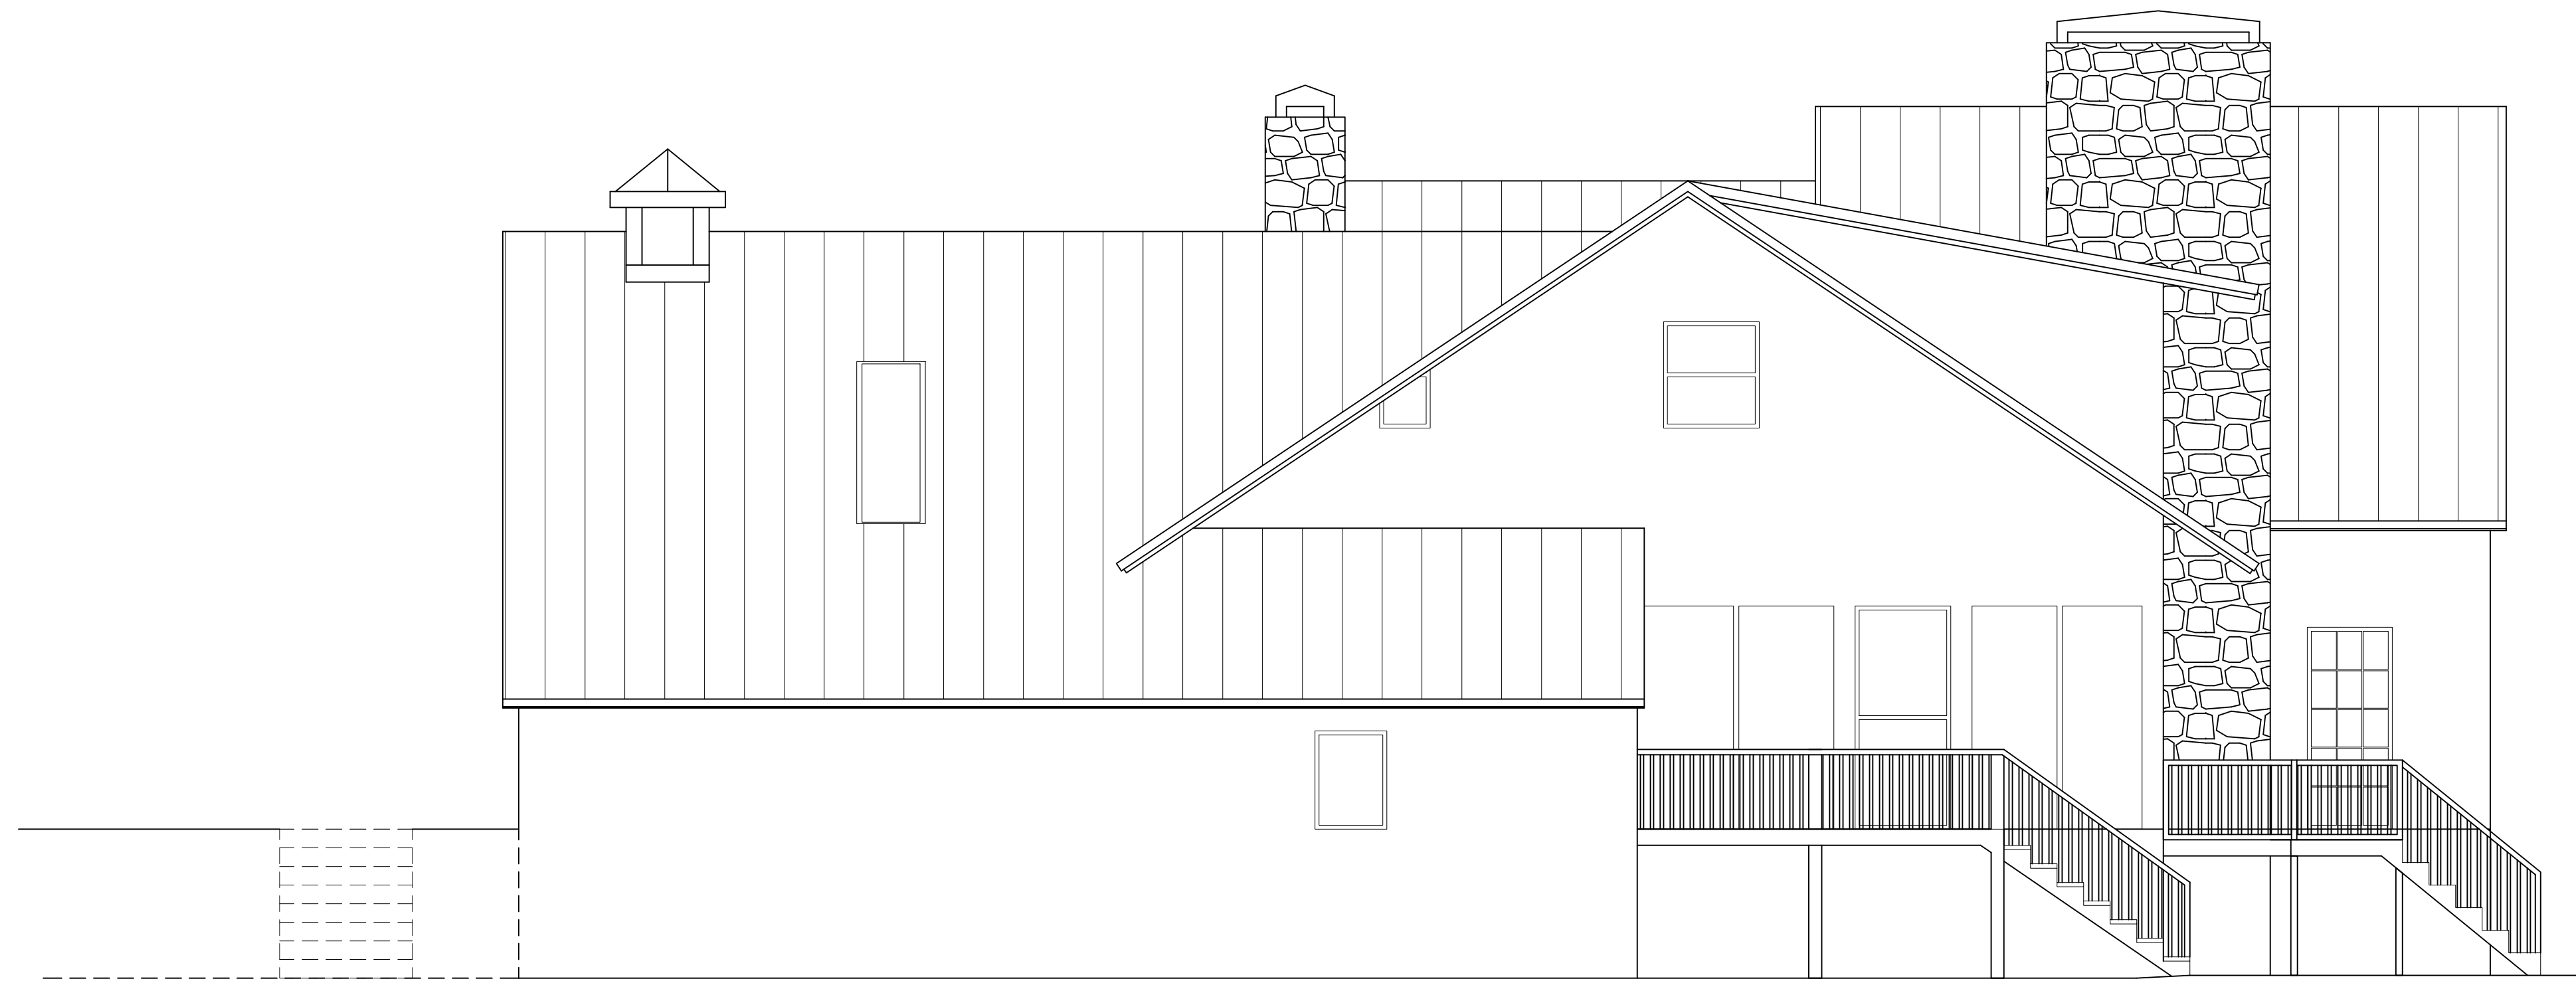
© 2011 AEC CONSULTANTS INC

ARCHITECTURAL AS BUILT

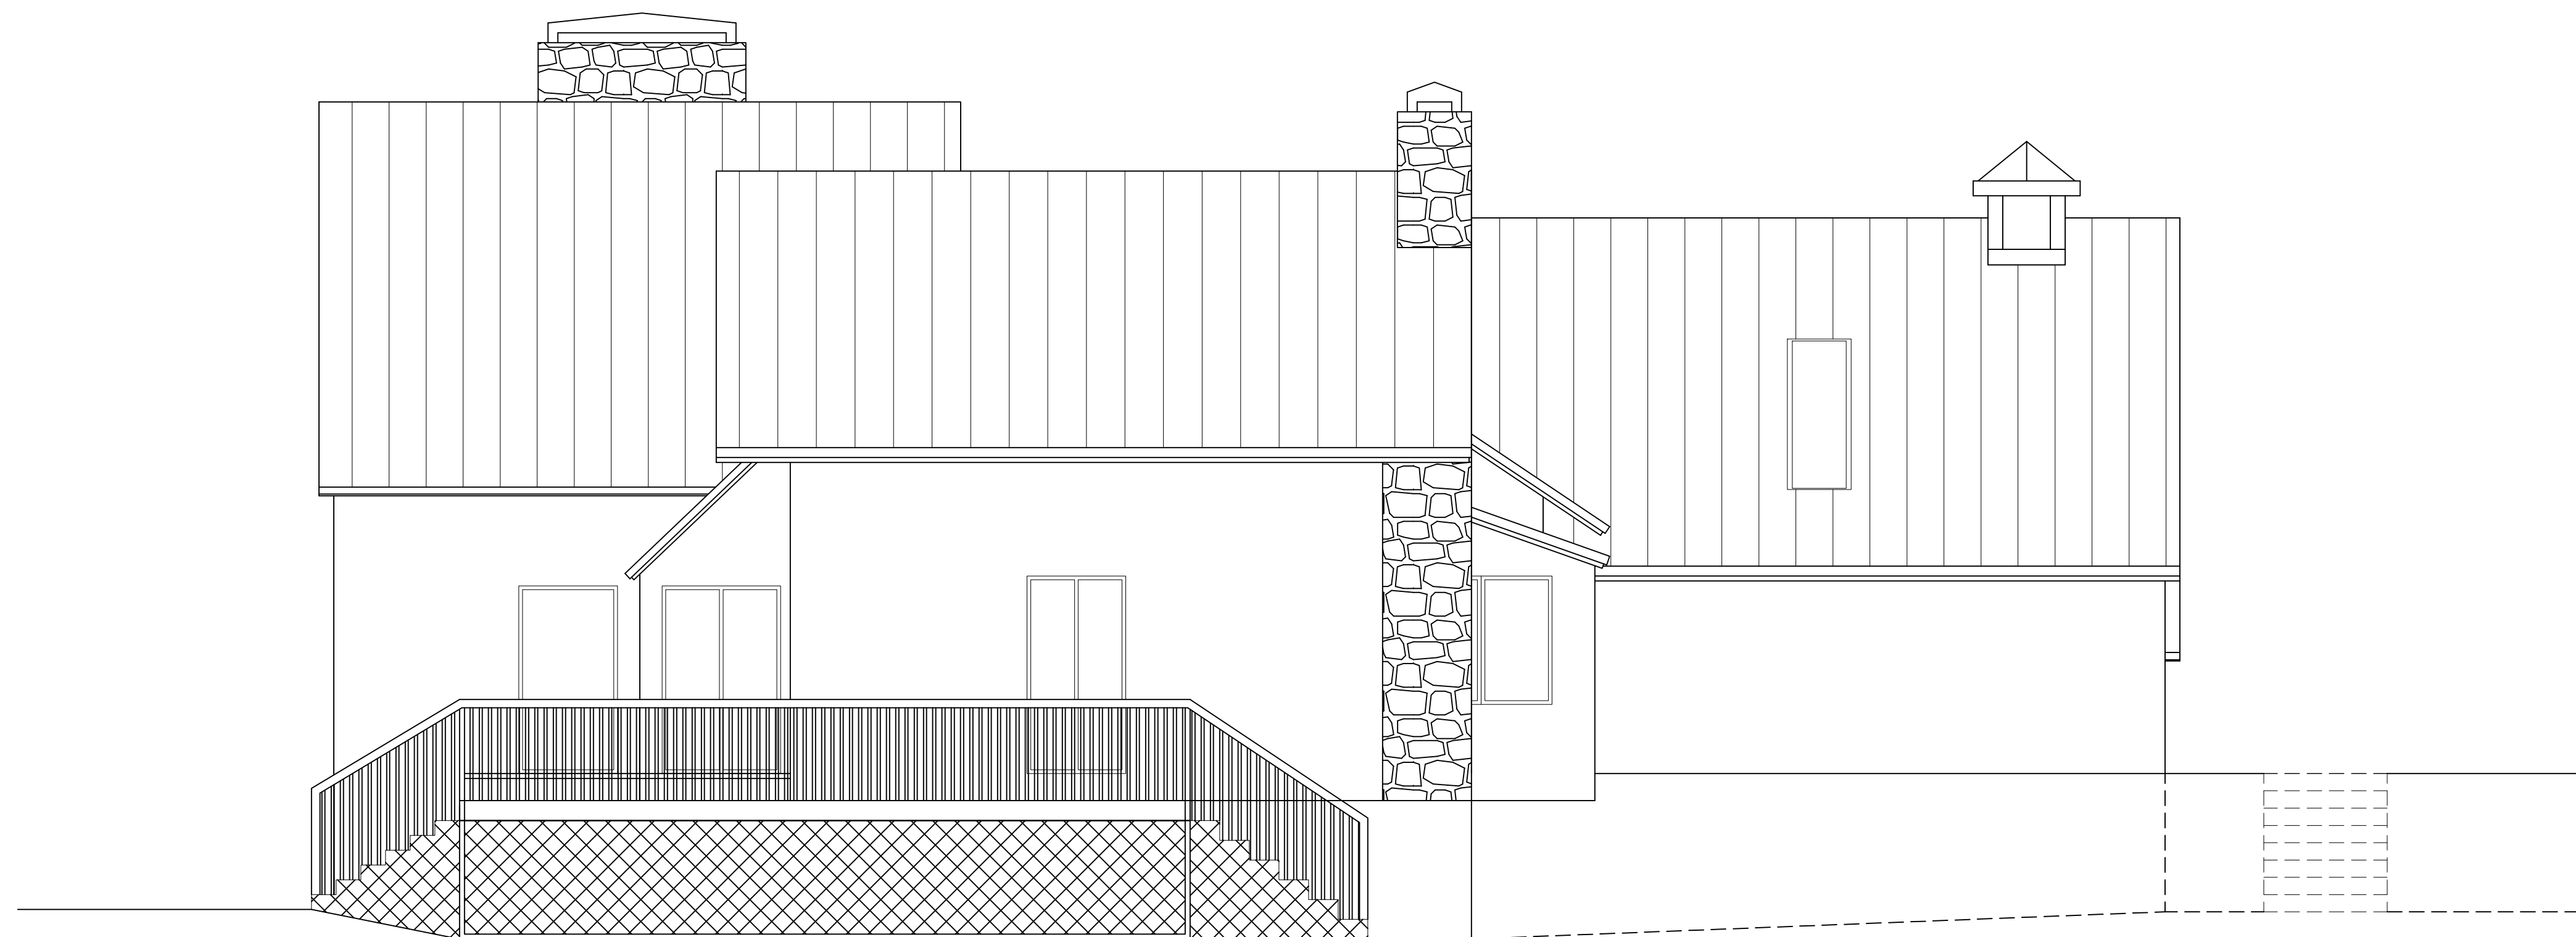
Chattanooga TN, 37419

01	100% SUBMISSION	
NO.	ISSUES REVISIONS	DATE
		SHEET TITLE
HL	PROJECT MANAGER	
HL	PROJECT DIRECTOR	
012317-1	PROJECT NUMBER	
1/4"=1'-0"	SCALE	
CL	DRAWN BY	
		SHEET NUMBER

AB-4



RIGHT SIDE ELEVATION



LEFT SIDE ELEVATION

 


ARCHITECTURAL AS BUILT

Chattanooga TN, 37419

[illegible]

AB-5



© 2017 AEC CONSULTANTS INC.

Chattanooga TN, 37419

SHEET NUMBER

AB-6