

AS-BUILT DOCUMENTATION

Private RESIDENCE

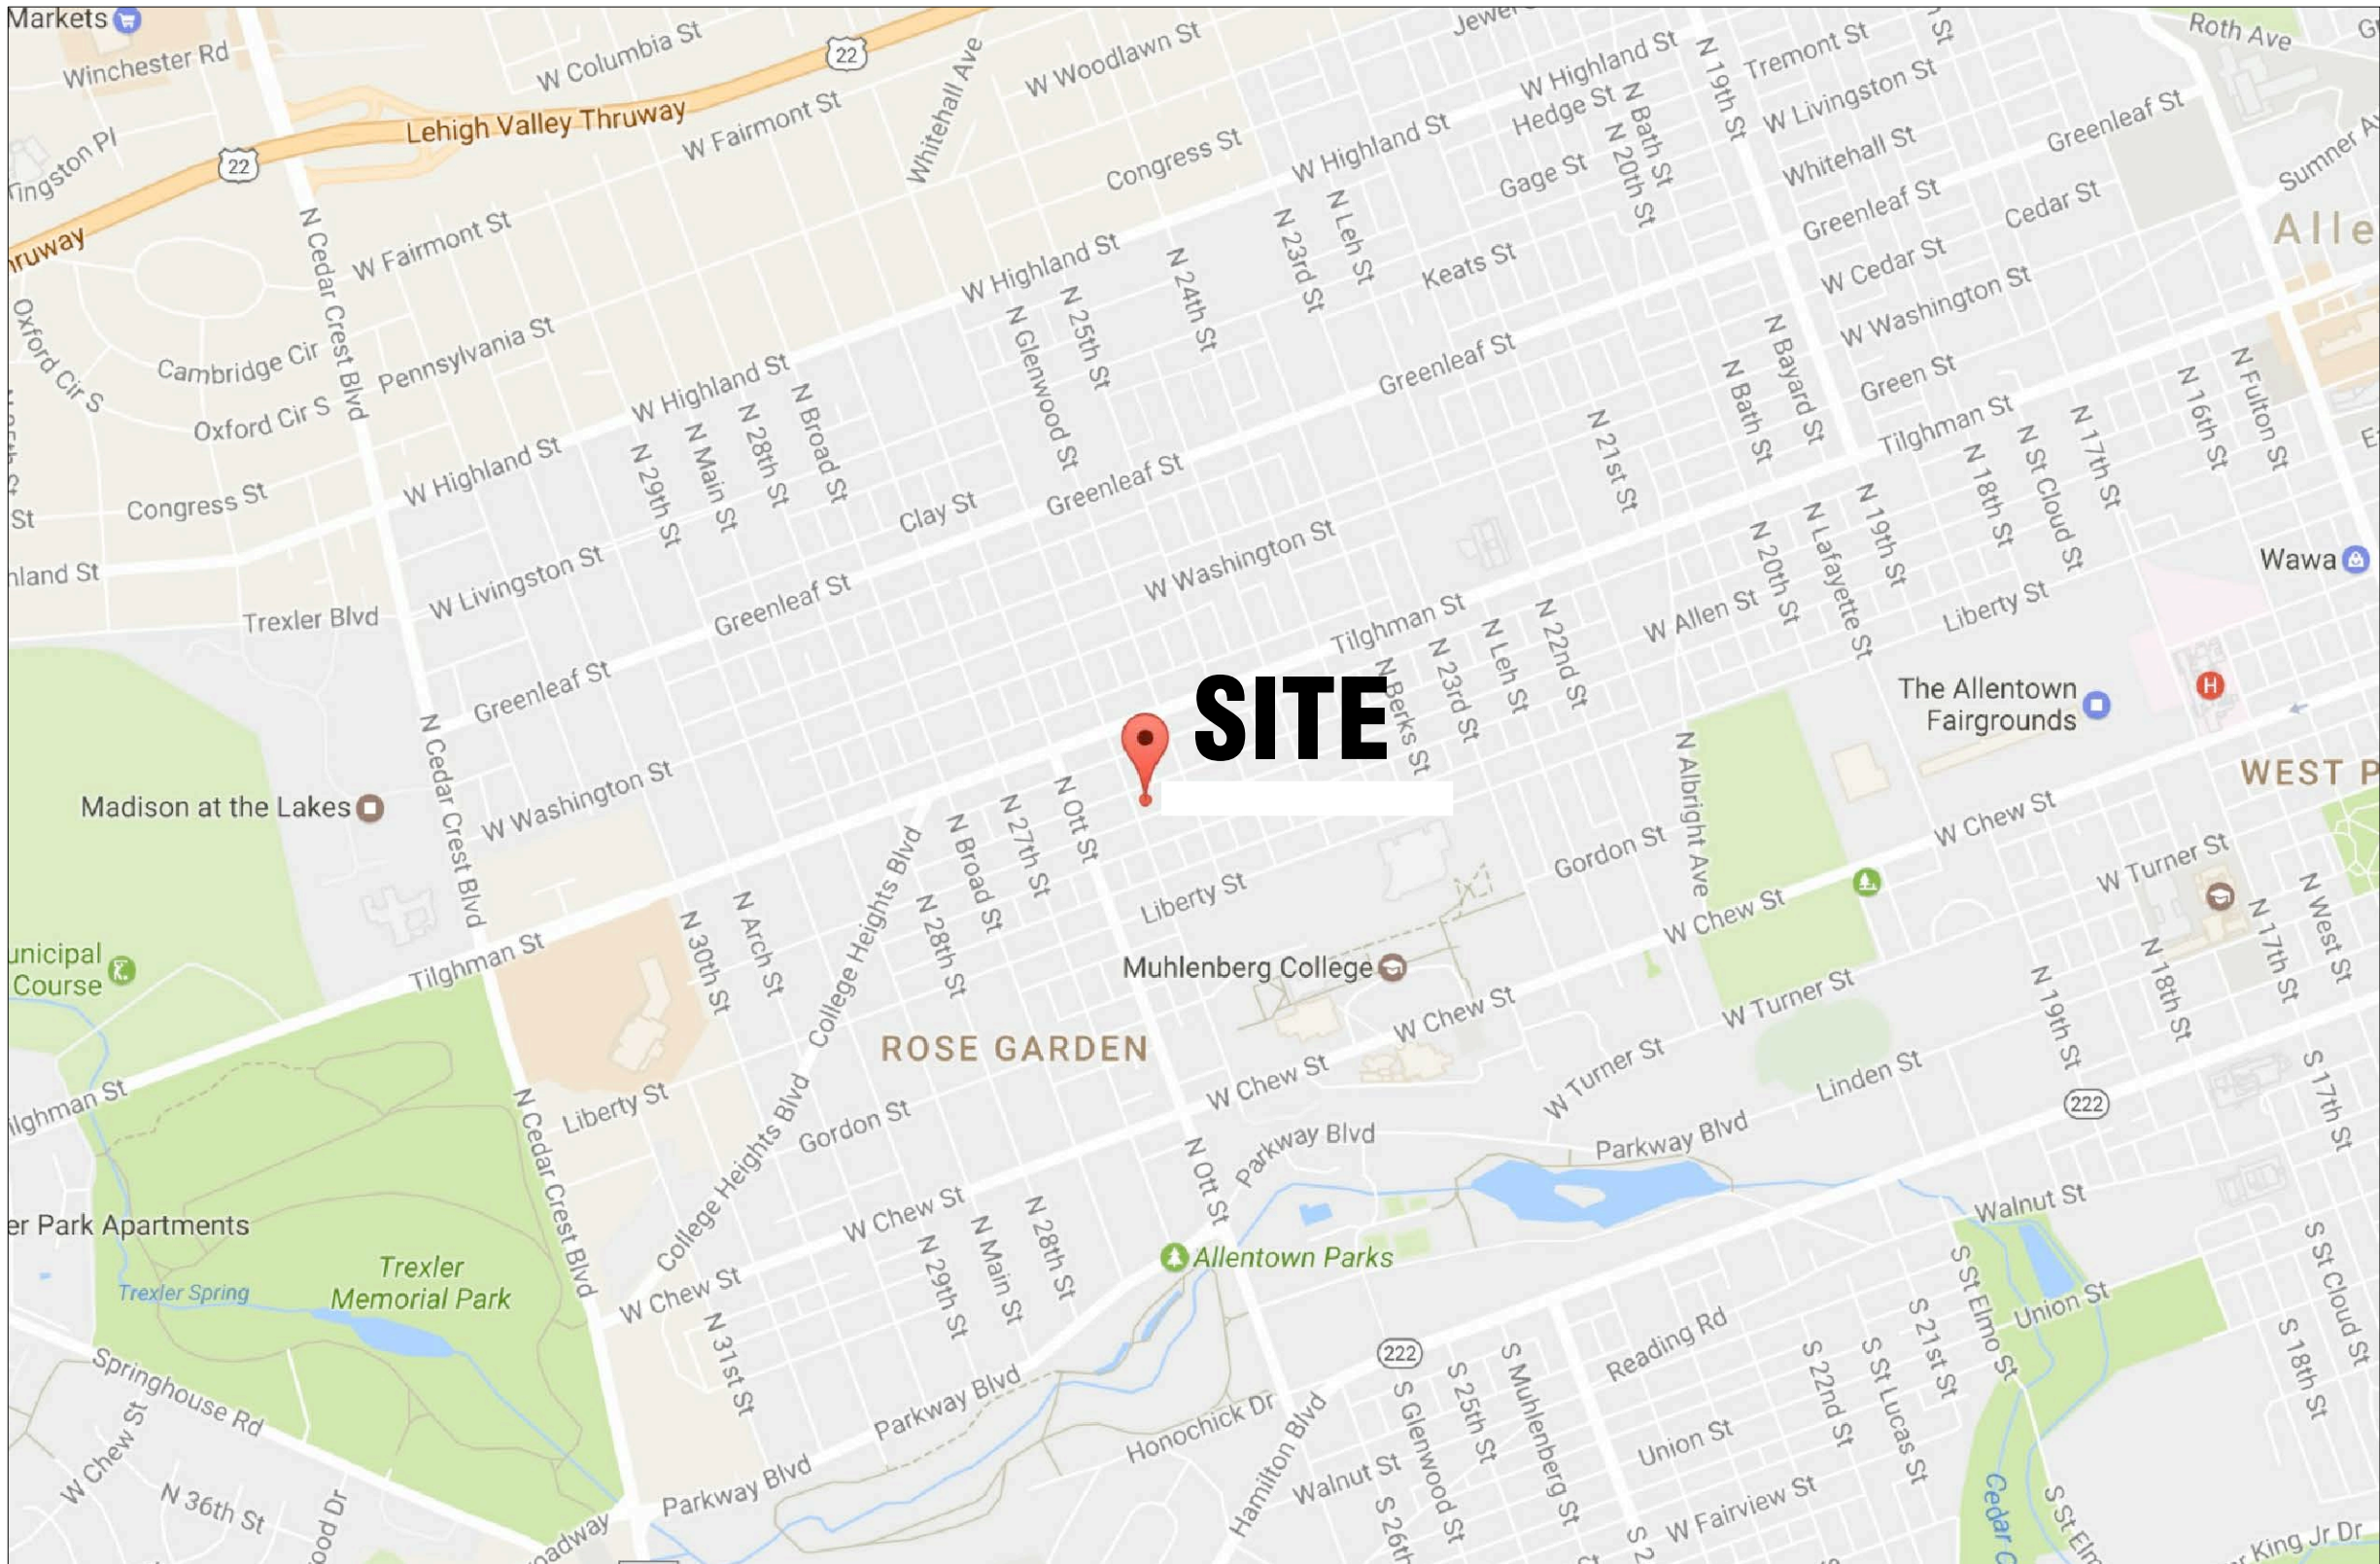
ALLENTOWN, PA 18108



100% SUBMITTAL

DRAWING INDEX

- C-1 COVER SHEET | DRAWING INDEX
- SL SYMBOLS LEGEND
- AB-1 BASEMENT FLOOR PLAN
- AB-2 FIRST FLOOR PLAN
- AB-3 SECOND FLOOR PLAN
- AB-4 THIRD FLOOR PLAN (FINISHED ATTIC)
- AB-5 EXTERIOR ELEVATIONS
- AB-6 EXTERIOR ELEVATIONS
- AB-7 EXTERIOR ELEVATIONS
- AB-8 EXTERIOR ELEVATIONS
- AB-9 LONGITUDINAL CROSS SECTION
- AB-10 TRANSVERSE CROSS SECTION



VICINITY MAP NTS

AREA DATA

BASEMENT	1,258 S.F.±
LIVING FIRST FLOOR	1,404 S.F.±
LIVING SECOND FLOOR	990 S.F.±
LIVING THIRD FLOOR (FINISHED ATTIC)	580 S.F.±
COVERED FRONT ENTRY	28 S.F.±
COVERED SIDE PORCH	142 S.F.±
GARAGE (NOT INCLUDED IN SCOPE)	0 S.F.±
GRAND TOTAL AREA MEASURED	4,402 S.F.±

As BUILT
PROFESSIONALS

A DIVISION OF:

AEC
CONSULTANTS INC

www.aecconsultantsinc.com

844.272.8458

© 2011 AEC CONSULTANTS INC








ARCHITECTURAL AS BUILT







ALLENTOWN, PA 18104

01	100% SUBMISSION	
NO.	ISSUES REVISIONS	DATE
SHEET TITLE		
COVER SHEET		
HL	PROJECT MANAGER	
HL	PROJECT DIRECTOR	
012317-1	PROJECT NUMBER	
	SCALE	
CL	DRAWN BY	
SHEET NUMBER		
C-1		

SYMBOLS LEGEND

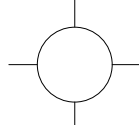   
 
 
 
RCP

  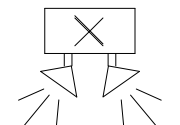 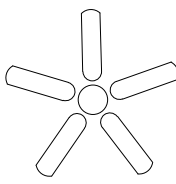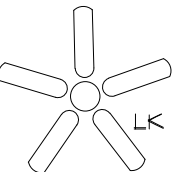-  EXHAUST VENT
-  CEILING MOUNTED LIGHT FIXTURE
-  CEILING MOUNTED DIRECTIONAL LIGHT
-  RECESSED CAN LIGHT
-  EYEBALL OR SMALL CAN LIGHT
-  PENDANT LIGHT
-  INDIVIDUAL FLUOR. LAY-IN FIXTURE 4 BULB
-  INDIVIDUAL FLUOR. HANGING FIXTURE 2 BULB
-  INDIVIDUAL FLUOR. FLUSH MOUNT FIXTURE 4 BULB
-  CAMERA
-  MOTION DET.
-  SUPPLY VENT
-  SUPPLY VENT
-  RETURN VENT
-  RETURN VENT
-  SPEAKER

-  TRACK LIGHT OR VANITY LIGHT
-  WALL-MOUNTED LIGHT FIXTURE
-  EMERGENCY EXIT SIGN
-  EMERGENCY EXIT LIGHT
-  EMERGENCY EXIT LIGHT W/ SIGN
-  LIGHTED STAIR SIGN
-  FLOOD LIGHT
-  PHOTO CELL
-  CEILING FAN
-  CEILING FAN W/ LIGHT KIT
-  JUNCTION BOX

7-2-6 CEILING HEIGHT AND TRIM 7'-2" ABOVE FLOOR BELOW WITH 6" CROWN MOULDING. NOTE: ALL CEILINGS NOT LABELED ARE PLASTER. CEILINGS SHOWN WITH A GRID ARE LAY IN ACOUSTICAL TILE..

    ELECTRIC

-  DATA OUTLET
-  TELEPHONE JACK
-  ELECTRIC SWITCH
-  CABLE TELEVISION OUTLET
-  DUPLEX RECEPTACLE OUTLET
-  SPECIAL PURPOSE CONNECTION OR OUTLET
-  QUADRUPLEX RECEPTACLE OUTLET
-  FLOOR DUPLEX RECEPTACLE OUTLET
-  ELECTRIC PANEL
-  ELECTRIC METER
-  BUTTON SWITCH
-  DISCONNECT SWITCH
-  GROUND/FLOOR LIGHT
-  KEY PAD

FIRE PROTECTION

-  FIRE EXTINGUISHER
-  FIRE PULL
-  FIRE ALARM (HORN/SRTOBE)
-  SMOKE DETECTOR
-  SMOKE ALARM SPEAKER
-  SPRINKLER HEAD CEILING MOUNT
-  SPRINKLER HEAD WALL MOUNT

MEP

-  THERMOSTAT
-  FLOOR DRAIN
-  VALVE
-  HOSE BIB
-  WATER SUPPLY
-  SUSPENDED GAS HEATER

MISC

-  BOLLARD

7-2-6

CEILING HEIGHT AND TRIM 7'-2" ABOVE FLOOR BELOW WITH 6" CROWN MOULDING. NOTE: ALL CEILINGS NOT LABELED ARE PLASTER. CEILINGS SHOWN WITH A GRID ARE LAY IN ACOUSTICAL TILE..

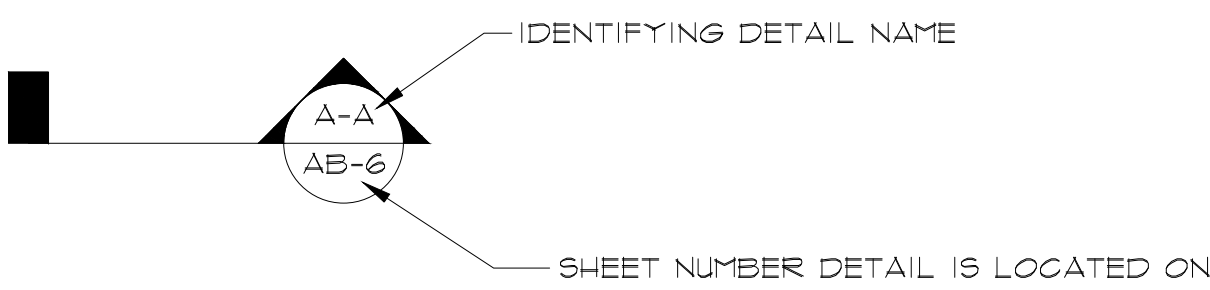
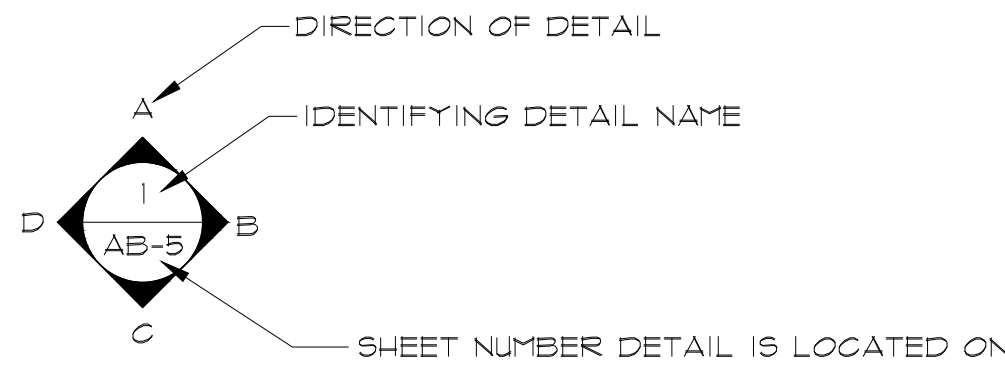
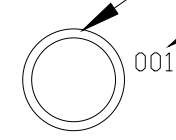
 
 
 
 


PHOTO DOCUMENTATION LEGEND

-  INDICATES LOCATION OF CAMERA
-  INDICATES DIRECTION OF CAMERA LENS AND CORRESPONDING PHOTO / VIDEO NUMBER

TYPES OF DOCUMENTATION

-  001 GROUND BASED PHOTO
-  V-001 GROUND BASED VIDEO
-  023 360° SPHERICAL PHOTO
-  001 AERIAL BASED PHOTO
-  V-001 AERIAL BASED VIDEO

AS BUILT
PROFESSIONALS
A DIVISION OF:

AEC
CONSULTANTS INC
www.aecconsultantsinc.com
844.272.8458


© 2011 AEC CONSULTANTS INC

ARCHITECTURAL AS BUILT

ALLENTOWN, PA 18104

01	100% SUBMISSION	
NO.	ISSUES REVISIONS	DATE
		SHEET TITLE
HL	PROJECT MANAGER	
HL	PROJECT DIRECTOR	
012317-1	PROJECT NUMBER	
NOT TO SCALE		SCALE
CL	DRAWN BY	
		SHEET NUMBER

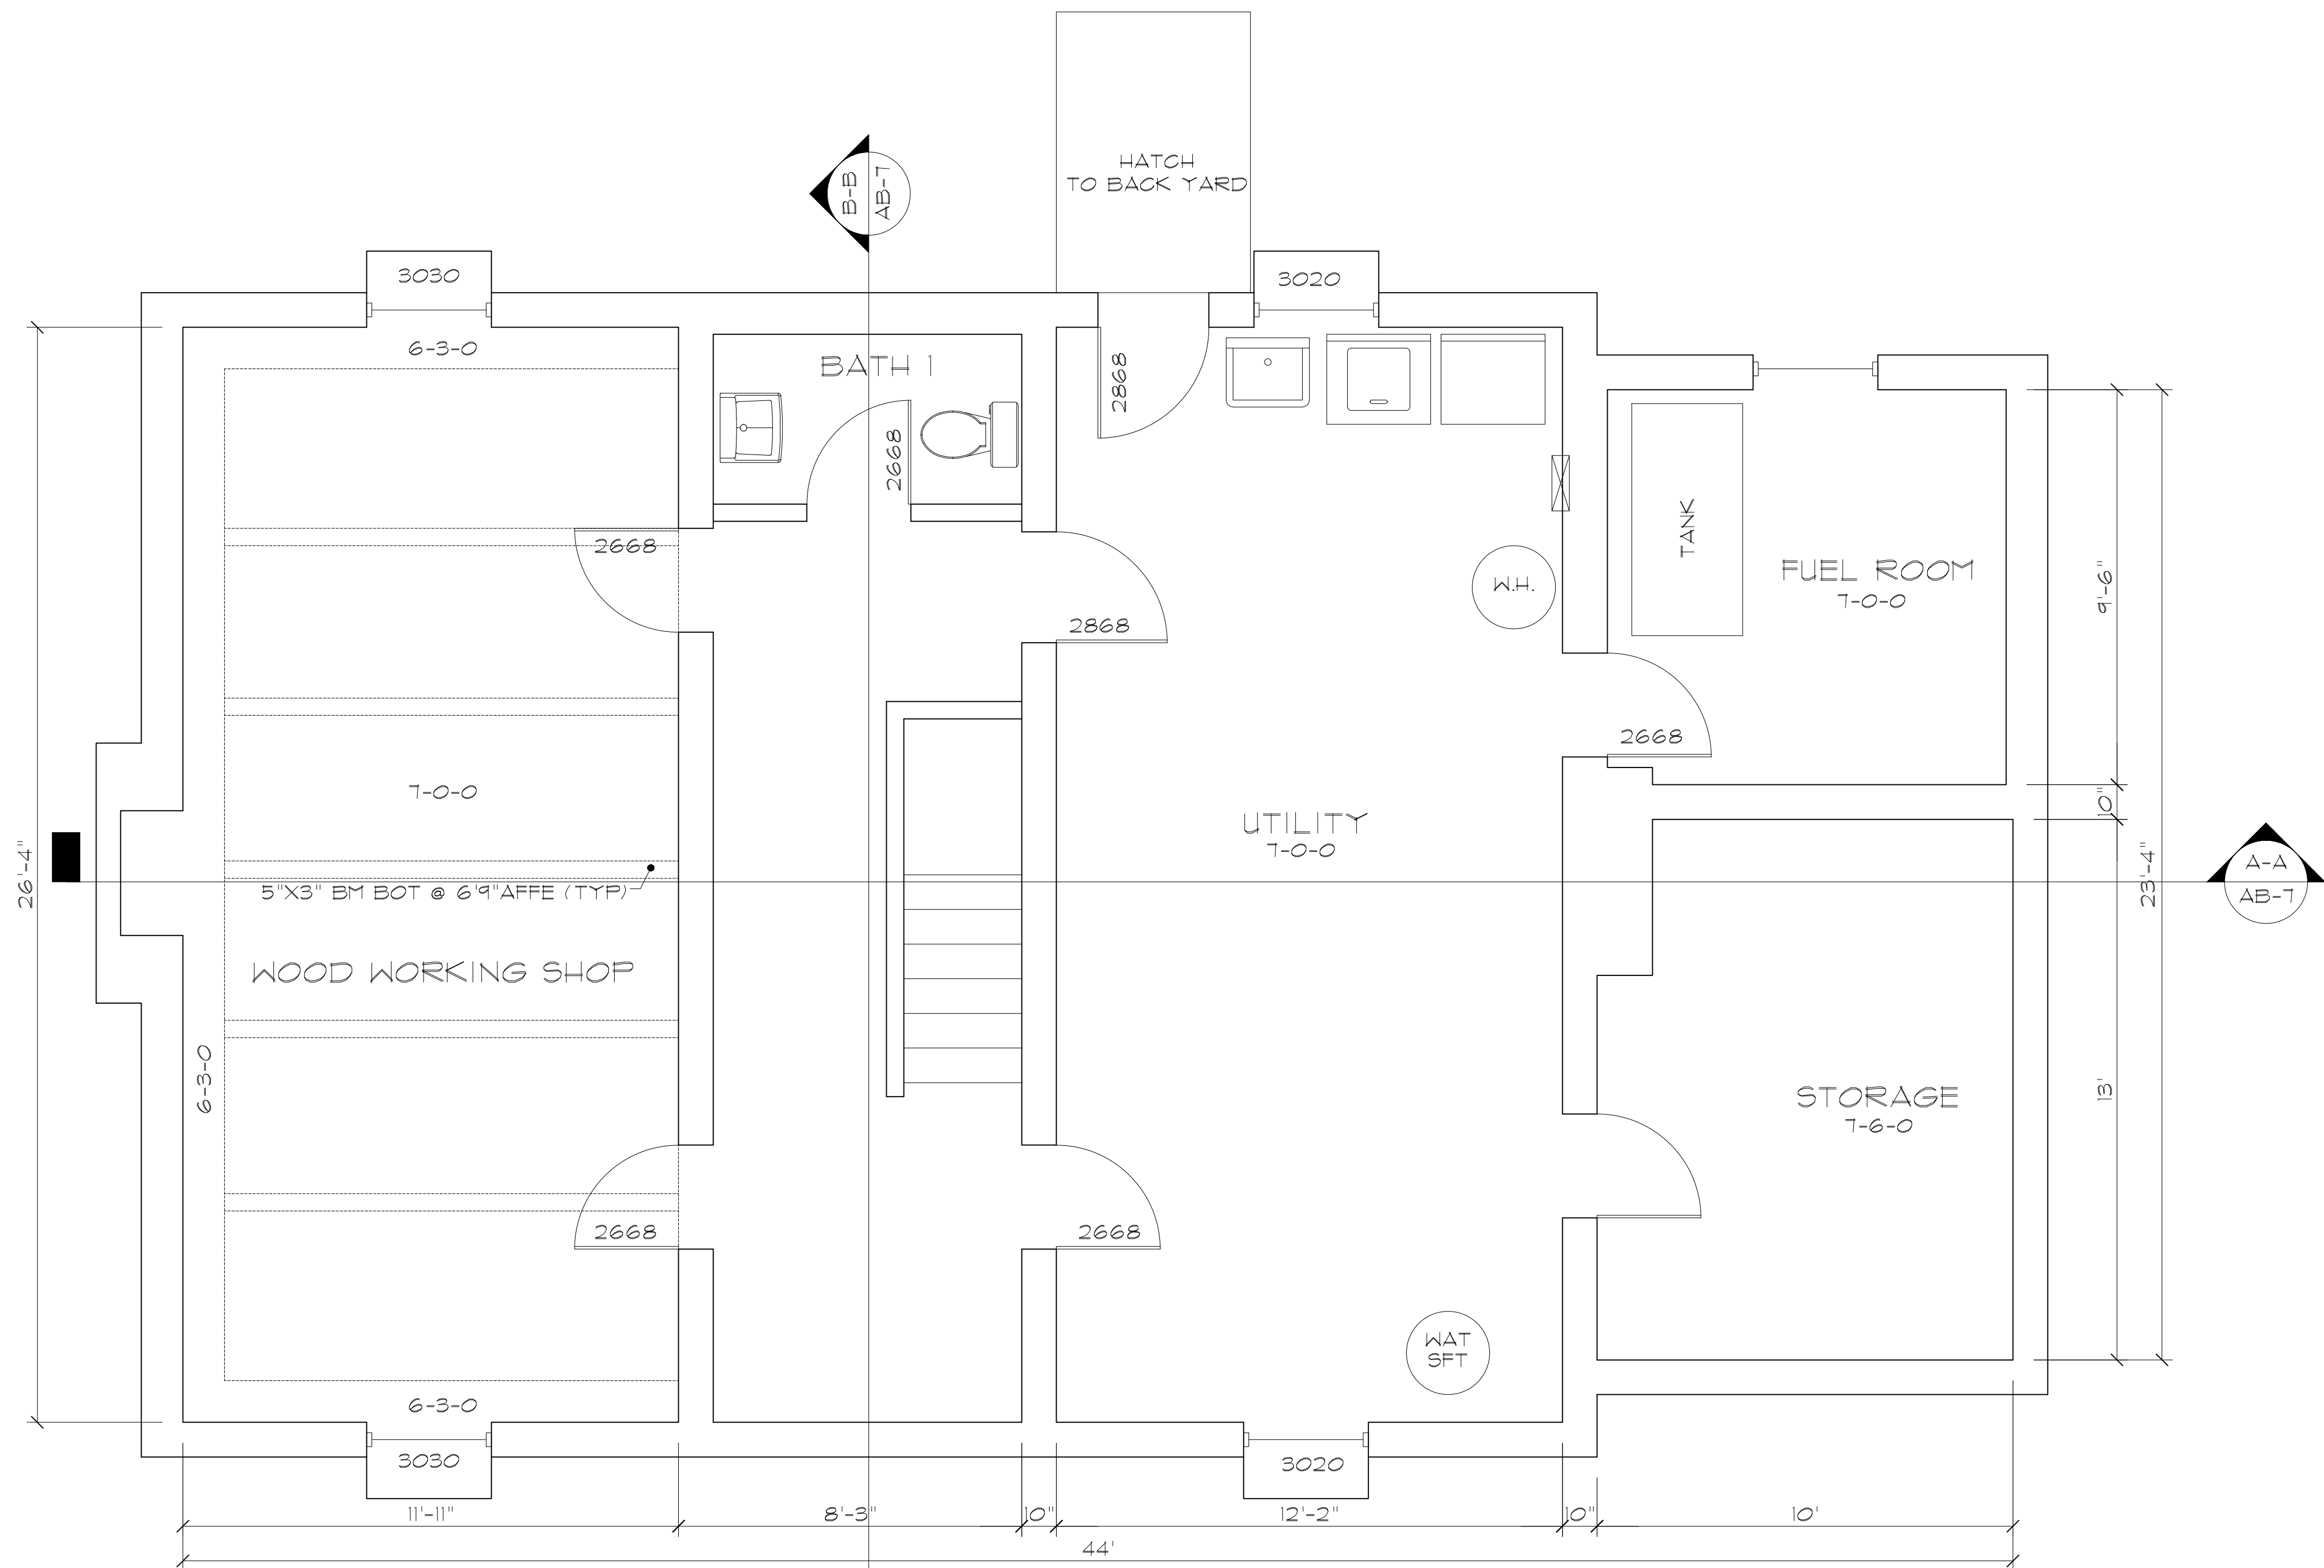SL



BASEMENT FLOOR PLAN

As BUILT

PROFESSIONALS

A DIVISION OF:

AEC

CONSULTANTS INC

www.aecconsultantsinc.com

844.272.8458

© 2011 AEC CONSULTANTS INC

ARCHITECTURAL AS BUILT

ALLENTOWN, PA 18104

01	100% SUBMISSION	
NO.	ISSUES REVISIONS	DATE
SHEET TITLE		
HL	PROJECT MANAGER	
HL	PROJECT DIRECTOR	
012317-1	PROJECT NUMBER	
3/8"=1'-0"	SCALE	
CL	DRAWN BY	
SHEET NUMBER		

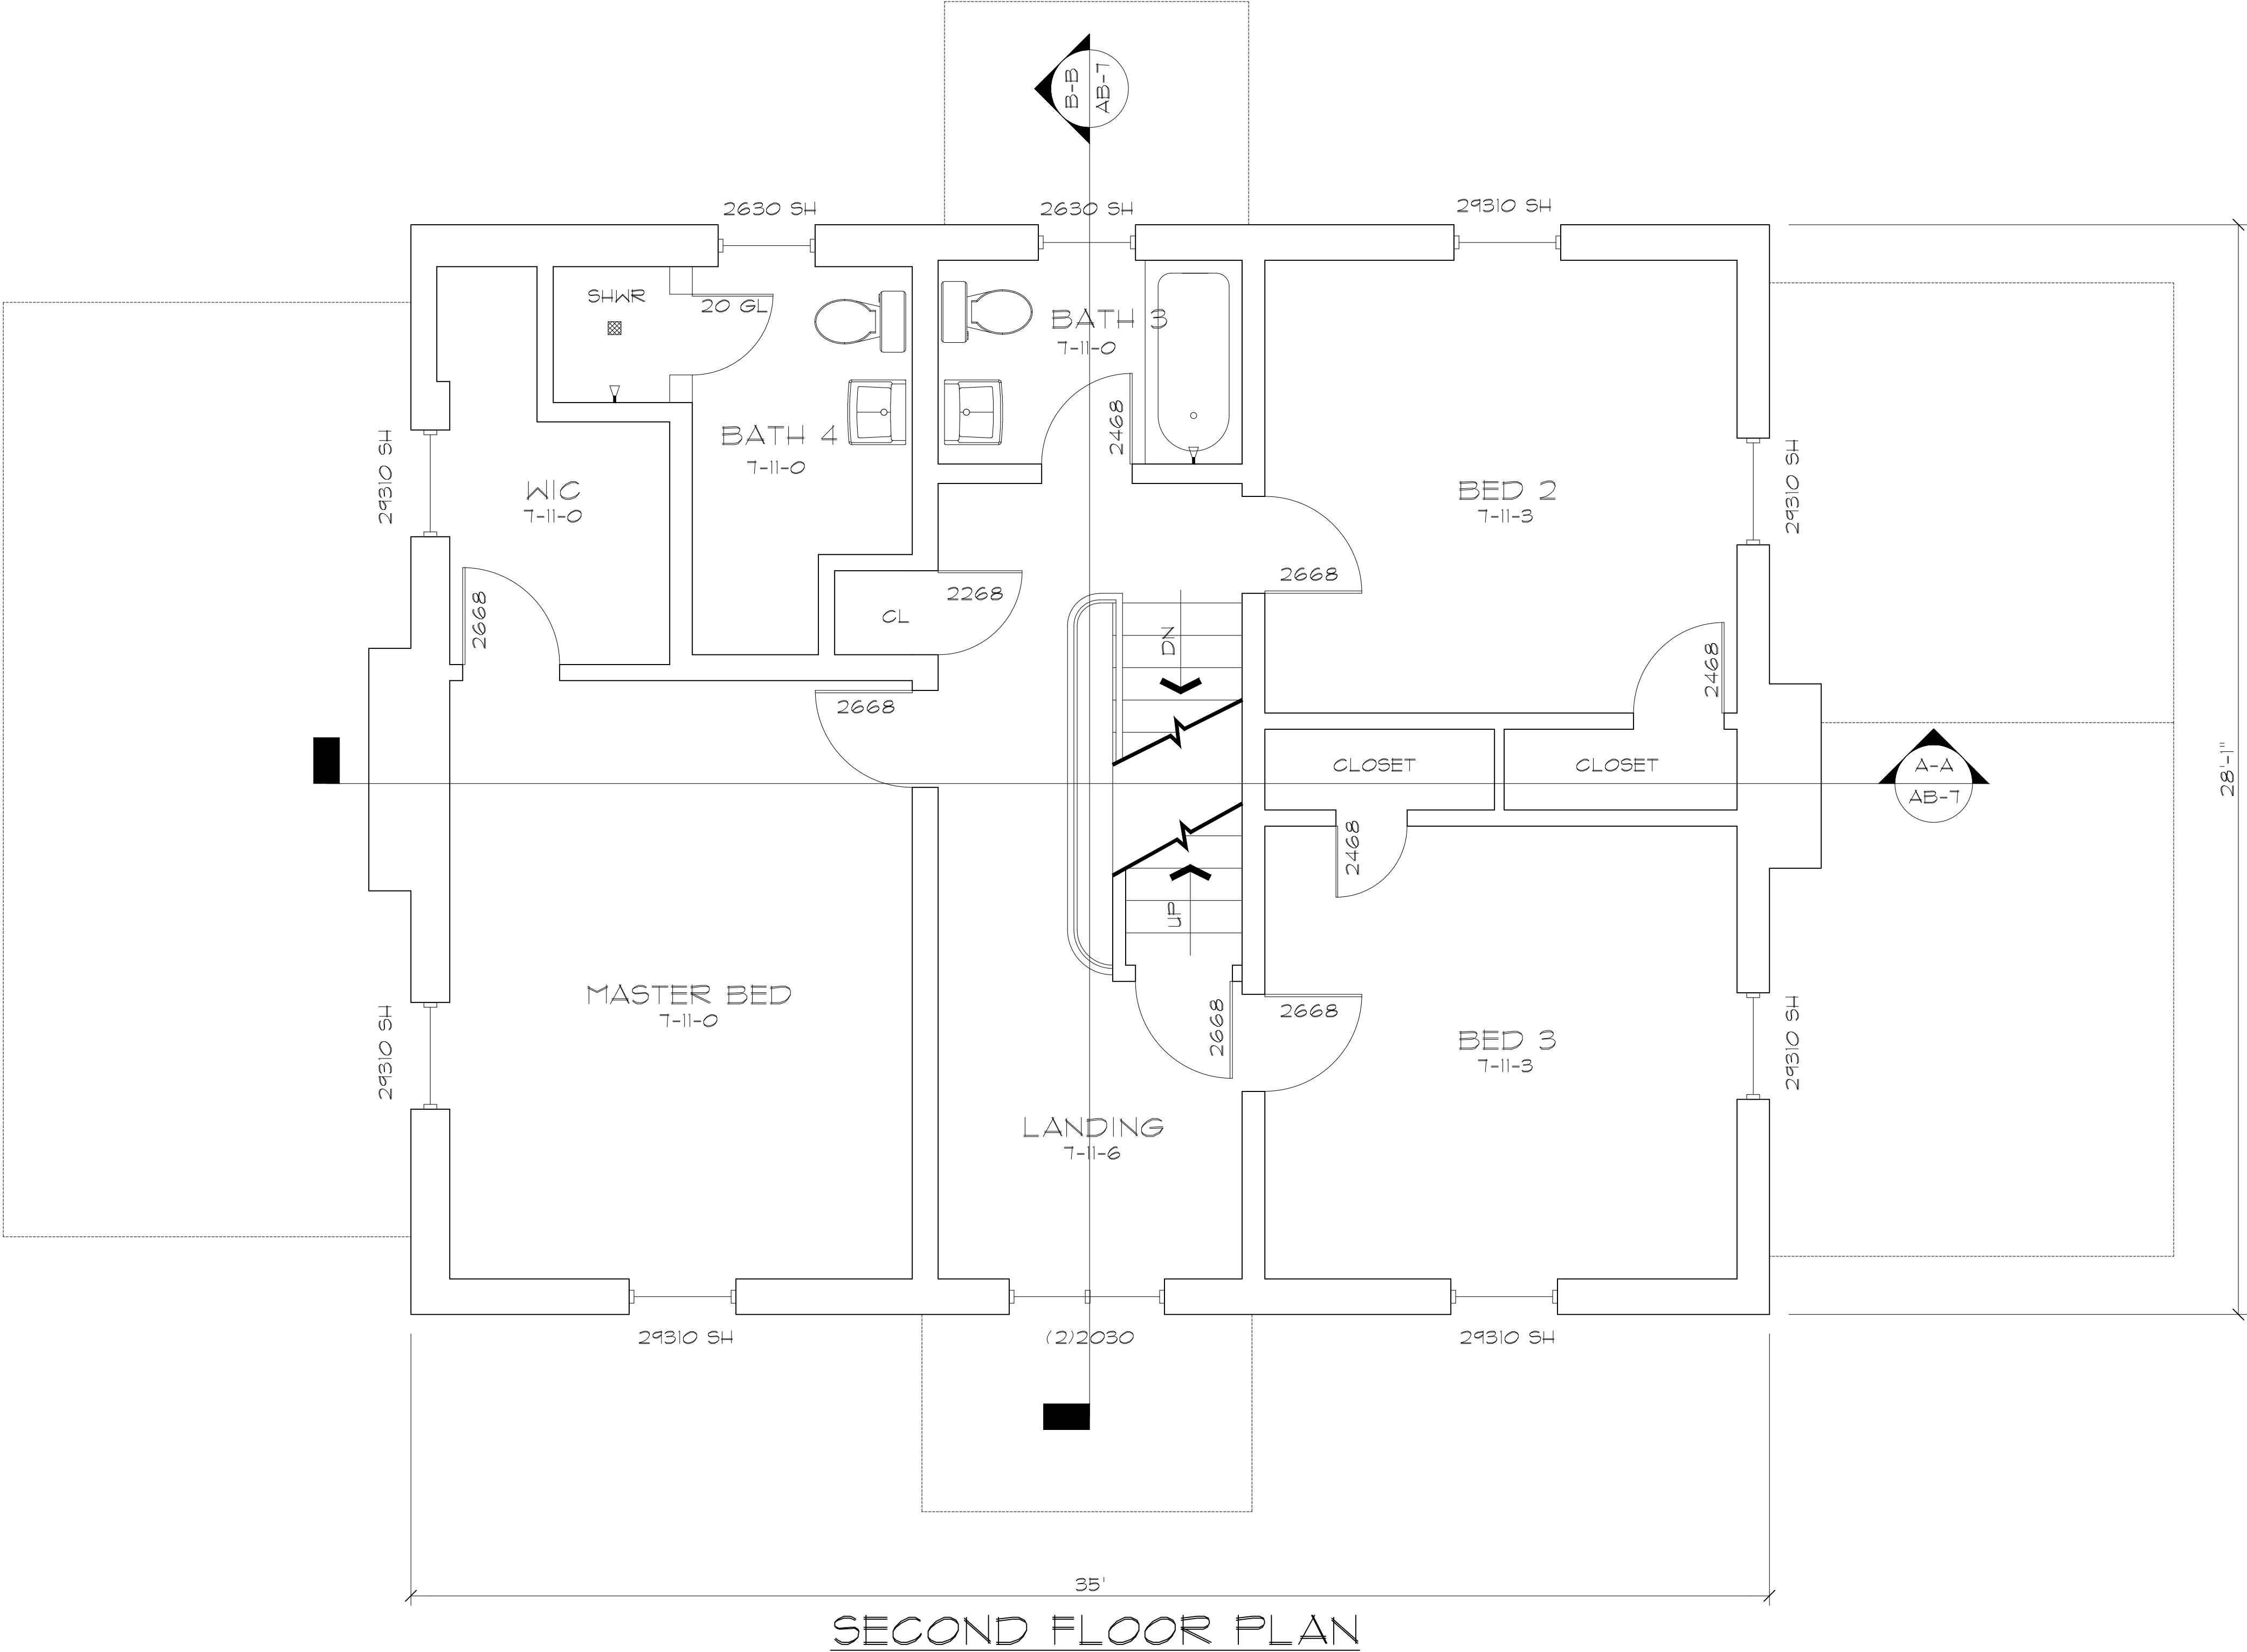
AB-1



ALLENTOWN, PA 18104

SHEET NUMBER

AB-2



As BUILT

PROFESSIONALS

A DIVISION OF:

AEC

CONSULTANTS INC

www.aecconsultantsinc.com


844.272.8458

© 2011 AEC CONSULTANTS INC

ARCHITECTURAL AS BUILT

ALLENTOWN, PA 18104

01	100% SUBMISSION	
NO.	ISSUES REVISIONS	DATE
		SHEET TITLE
HL		PROJECT MANAGER
HL		PROJECT DIRECTOR
012317-1		PROJECT NUMBER
3/8"=1'-0"		SCALE
CL		DRAWN BY
		SHEET NUMBER
AB-3		

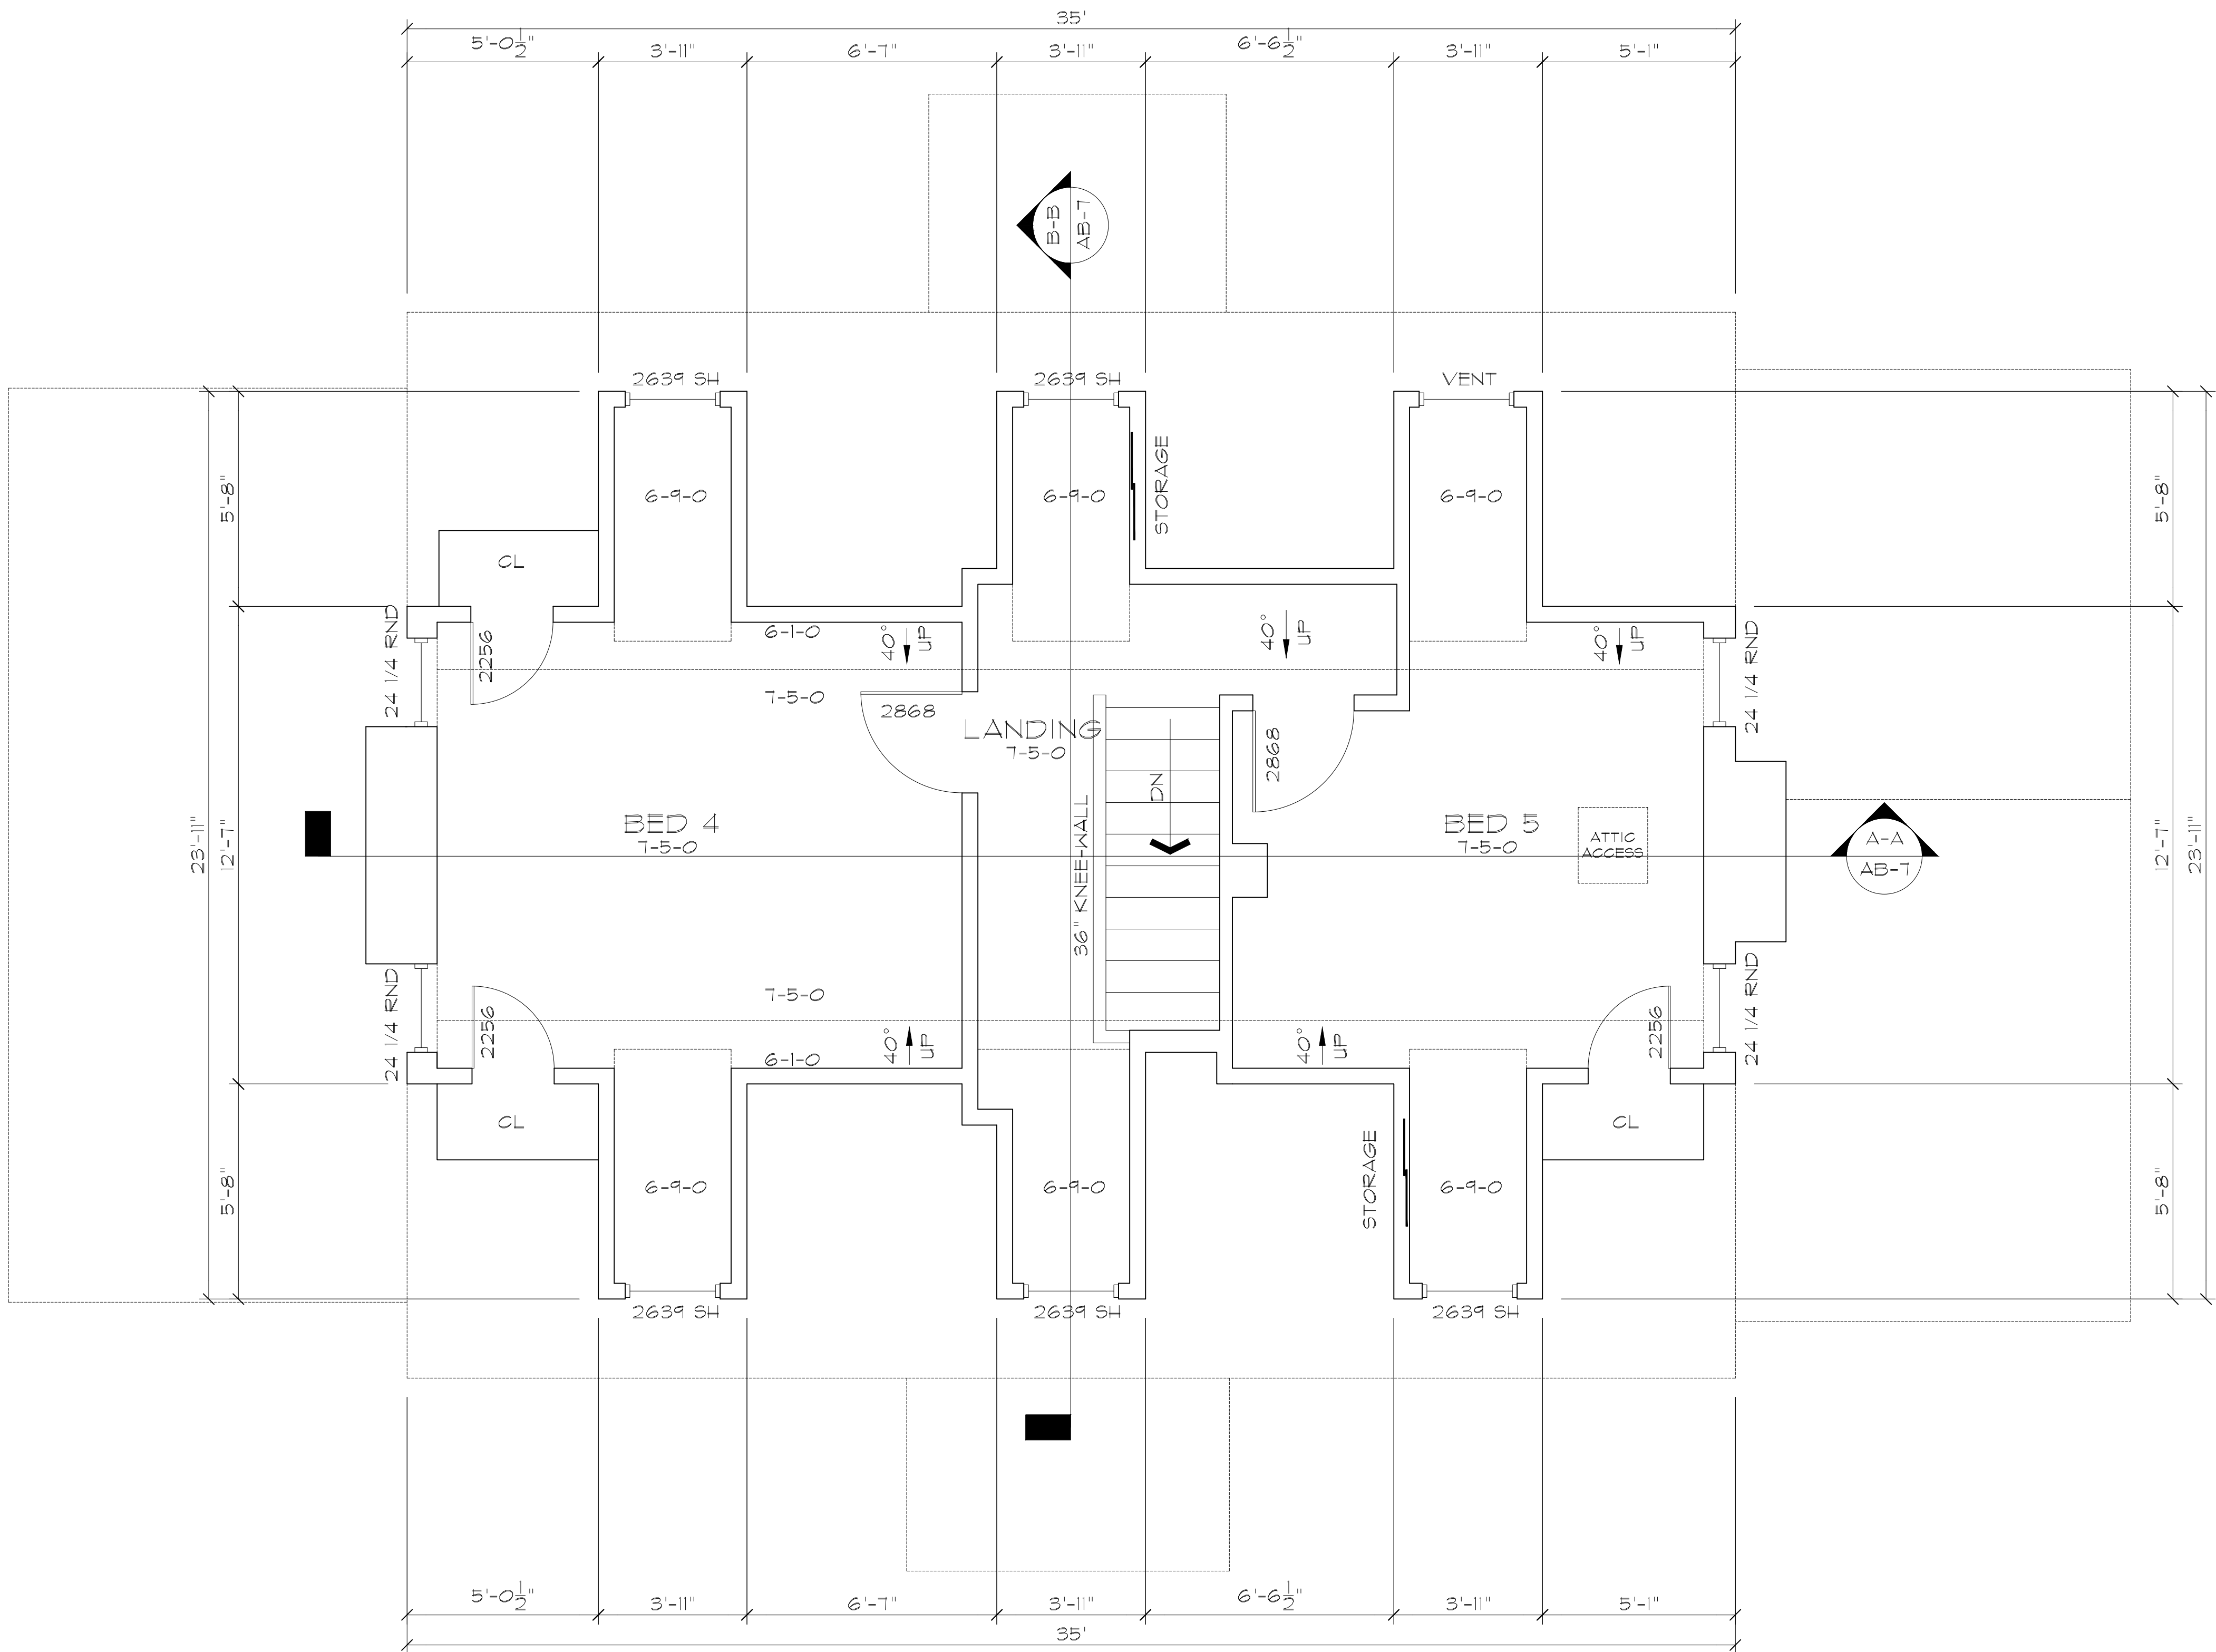

THIRD FLOOR PLAN (FINISHED ATTIC)

As BUILT
PROFESSIONALS

A DIVISION OF:

AEC

CONSULTANTS INC

www.aecconsultantsinc.com

844.272.8458

© 2011 AEC CONSULTANTS INC

ARCHITECTURAL AS BUILT

ALLENTOWN, PA 18104

01	100% SUBMISSION
NO.	ISSUES REVISIONS

SHEET TITLE

HL	PROJECT MANAGER
HL	PROJECT DIRECTOR
012317-1	PROJECT NUMBER
3/8"=1'-0"	SCALE
CL	DRAWN BY

SHEET NUMBER

AB-4

ROOF 30'-1".....

DORMER 27'-2".....

CLG 25'-7".....

DORMER 20'-2".....

FLOOR 18'-2".....

CLG 17'-4".....

WINDOW 16'-2".....

ENTRY ROOF #TOP OF RAIL 11'-7".....

FLOOR 9'-5".....

CLG 8'-6".....

WINDOW 7'-2".....

FLOOR 0'-0".....

BSMNT CLG -(1'-0").....

BSMNT FLOOR -(8'-0").....

ROOF 17'-8".....

DEN ROOF 9'-1".....

ENTRY ROOF 8'-8".....



As BUILT

PROFESSIONALS

A DIVISION OF:

AEC

CONSULTANTS INC

www.aecconsultantsinc.com

844.272.8458

© 2011 AEC CONSULTANTS INC

ARCHITECTURAL AS BUILT

ALLENTOWN, PA 18104

01	100% SUBMISSION	
NO.	ISSUES REVISIONS	DATE
		SHEET TITLE



As BUILT

PROFESSIONALS

A DIVISION OF:

AEC

CONSULTANTS INC

www.aecconsultantsinc.com

844.272.8458

© 2011 AEC CONSULTANTS INC

ARCHITECTURAL AS BUILT

ALLENTOWN, PA 18104

01	100% SUBMISSION	
NO.	ISSUES REVISIONS	DATE
SHEET TITLE		
HL	PROJECT MANAGER	
HL	PROJECT DIRECTOR	
012317-1	PROJECT NUMBER	
3/8"=1'-0"	SCALE	
CL	DRAWN BY	
SHEET NUMBER		

AB-6

ROOF 30'-1"

DORMER 27'-2"

CLG 25'-7"

DORMER 20'-2"

FLOOR 18'-2" ROOF 17'-8"
CLG 17'-4"

WINDOW 16'-2"

ENTRY ROOF & TOP OF RAIL 11'-7"

FLOOR 9'-5" DEN ROOF 9'-1"
CLG 8'-6" ENTRY ROOF 8'-8"

WINDOW 7'-2"

FLOOR 0'-0"

BSMNT CLG -(1'-0")

BSMNT FLOOR -(8'-0")



LEFT SIDE ELEVATION

As BUILT
PROFESSIONALS

A DIVISION OF:

AEC

CONSULTANTS INC

www.aecconsultantsinc.com

844.272.8458

© 2011 AEC CONSULTANTS INC

ARCHITECTURAL AS BUILT

ALLENTOWN, PA 18104

01	100% SUBMISSION	
NO.	ISSUES REVISIONS	DATE
		SHEET TITLE
HL	PROJECT MANAGER	
HL	PROJECT DIRECTOR	
012317-1	PROJECT NUMBER	
3/8"=1'-0"		SCALE
CL	DRAWN BY	
		SHEET NUMBER

AB-7

A DIVISION OF:

CONSULTANTS INC

www.aecconsultantsinc.com

844.272.8458

© 2017 AEC CONSULTANTS INC

ALLENTOWN, PA 18104

01	100% SUBMISSION	
----	-----------------	--

NO.	ISSUES REVISIONS	DATE
-----	--------------------	------

ET TITLE

HL	PROJECT MANAGER
----	-----------------

HL	PROJECT DIRECTOR
----	------------------

012317-1	PROJECT NUMBER
----------	----------------

$3/8"=1'-0"$ SCALE

CL	DRAWN BY
----	----------

SHEET NUMBER

AB-8



ALLENTOWN, PA 18104

AB-9



ALLENTOWN, PA 18104

AB-10