

AS-BUILT DOCUMENTATION

Private Residence

Indian Wells, CA 92210



100% SUBMITTAL

DRAWING INDEX

- C-1 COVER SHEET | DRAWING INDEX
- SL SYMBOLS LEGEND
- AB-1 SITE PLAN
- AB-2 FLOOR PLAN
- AB-3 REFLECTED CEILING PLAN
- AB-4 ROOF PLAN
- AB-5 INTERIOR ELEVATIONS
- AB-6 INTERIOR ELEVATIONS



N VICINITY MAP
NTS

AREA DATA	
LIVING ROOM	934 S.F. ±
KITCHEN & MORNING ROOM	504 S.F. ±
LIBRARY	364 S.F. ±
GUEST SUITE	585 S.F. ±
ENTIRE MASTER SUITE	1,528 S.F. ±
DINING ROOM	434 S.F. ±
GARAGE	961 S.F. ±
ENTRY	220 S.F. ±
POWDER ROOM	104 S.F. ±
BUTLER'S PANTRY	156 S.F. ±
LAUNDRY	140 S.F. ±
CLOSETS & CORRIDORS	1,093 S.F. ±
GRAND TOTAL	7,023 S.F. ±

ARCHITECTURAL AS BUILT

INDIAN WELLS, CA 92210



COVER
SHEET

HL PROJECT MANAGER
HL PROJECT DIRECTOR
PROJECT NUMBER
SCALE
MM DRAWN BY
SHEET NUMBER

C-1

SYMBOLS LEGEND

RCP

	EXHAUST VENT
	CEILING MOUNTED LIGHT FIXTURE
	CEILING MOUNTED DIRECTIONAL LIGHT
	RECESSED CAN LIGHT
	EYEBALL OR SMALL CAN LIGHT
	PENDANT LIGHT
	INDIVIDUAL FLUOR. LAY-IN FIXTURE 4 BULB
	INDIVIDUAL FLUOR. HANGING FIXTURE 2 BULB
	INDIVIDUAL FLUOR. FLUSH MOUNT FIXTURE 4 BULB
	CAMERA
	MOTION DET.
	SUPPLY VENT
	SUPPLY VENT
	RETURN VENT
	RETURN VENT
	SPEAKER

7-2-6

	TRACK LIGHT OR VANITY LIGHT
	WALL-MOUNTED LIGHT FIXTURE
	EMERGENCY EXIT SIGN
	EMERGENCY EXIT LIGHT
	EMERGENCY EXIT LIGHT W/ SIGN
	LIGHTED STAIR SIGN
	FLOOD LIGHT
	PHOTO CELL
	CEILING FAN
	CEILING FAN W/ LIGHT KIT
	JUNCTION BOX

ELECTRIC

	DATA OUTLET
	TELEPHONE JACK
	ELECTRIC SWITCH
	CABLE TELEVISION OUTLET
	DUPLEX RECEPTACLE OUTLET
	SPECIAL PURPOSE CONNECTION OR OUTLET
	QUADRUPLEX RECEPTACLE OUTLET
	FLOOR DUPLEX RECEPTACLE OUTLET
	ELECTRIC PANEL
	ELECTRIC METER
	BUTTON SWITCH
	DISCONNECT SWITCH
	GROUND/FLOOR LIGHT
	KEY PAD

FIRE PROTECTION

	FIRE EXTINGUISHER
	FIRE PULL
	FIRE ALARM (HORN/SRTOBE)
	SMOKE DETECTOR
	SMOKE ALARM SPEAKER
	SPRINKLER HEAD CEILING MOUNT
	SPRINKLER HEAD WALL MOUNT


MEP

	THERMOSTAT
	FLOOR DRAIN
	VALVE
	HOSE BIB
	WATER SUPPLY
	SUSPENDED GAS HEATER



MISC

	BOLLARD
	11-4-11/16 SPOT ELEVATION

INTERIOR ELEVATIONS

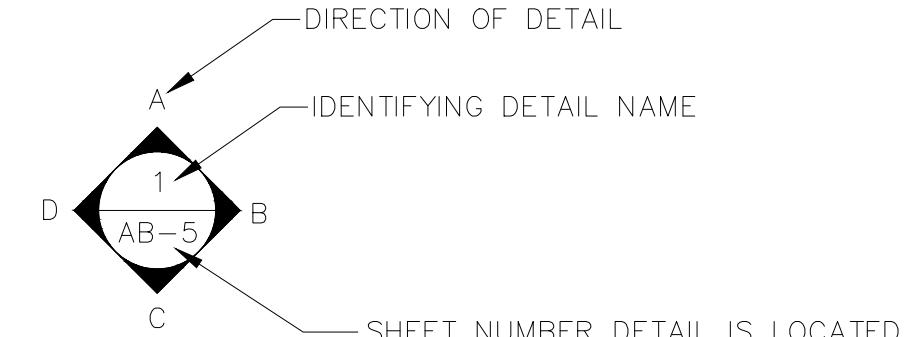

BUILDING SECTION

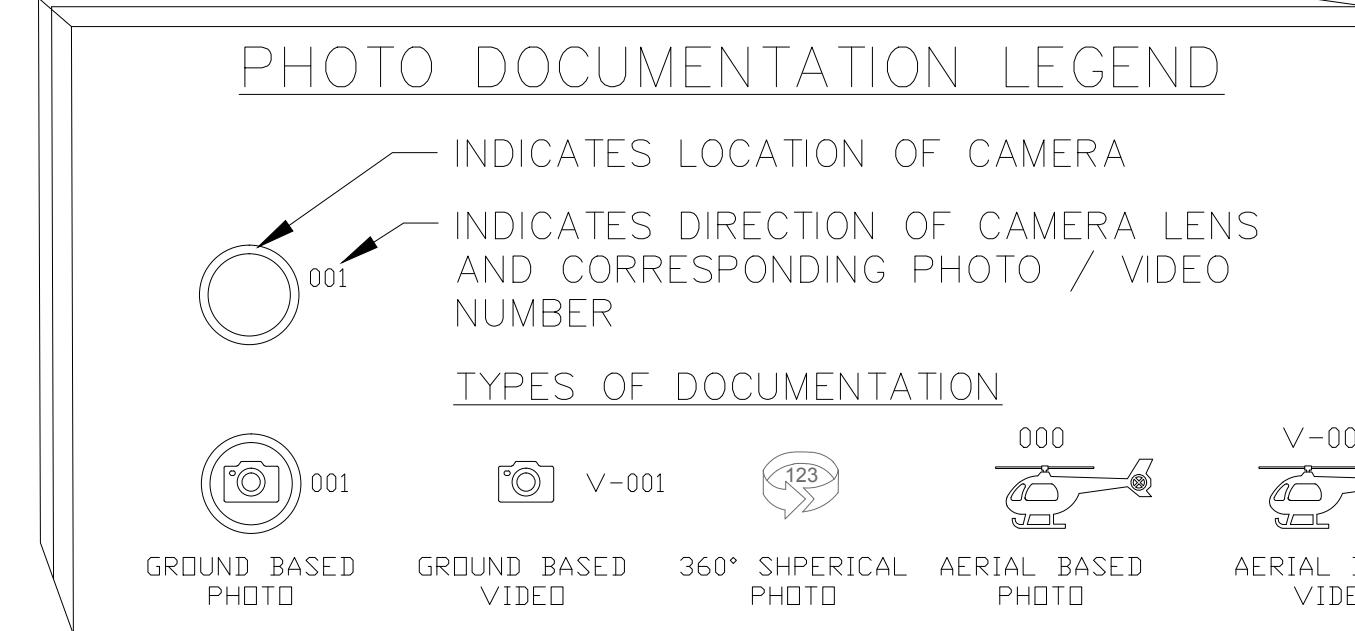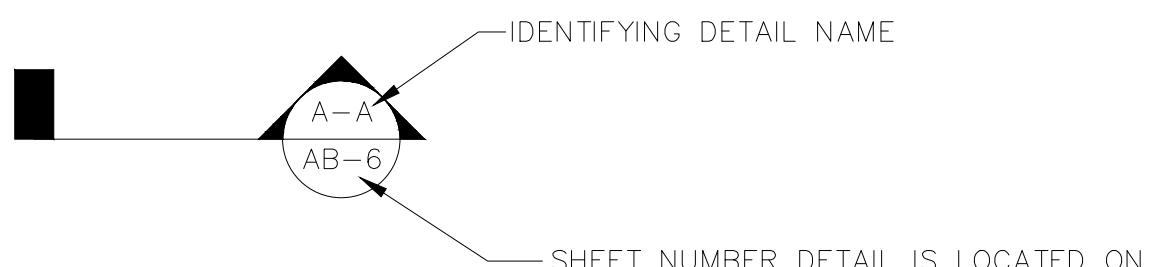

ARCHITECTURAL AS BUILT

02	_____	
01	_____	
NO.	ISSUES REVISIONS	DATE
	SHEET TITLE	
HL	PROJECT MANAGER	
HL	PROJECT DIRECTOR	
	PROJECT NUMBER	
NOT TO SCALE	SCALE	
MM	DRAWN BY	
	SHEET NUMBER	
SL		





© 2017 AEC CONSULTANTS INC

INDIAN WELLS, CA 92210

ARCHITECTURAL AS BUILT

SITE PLAN

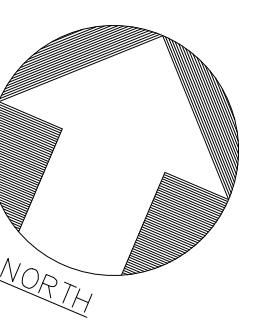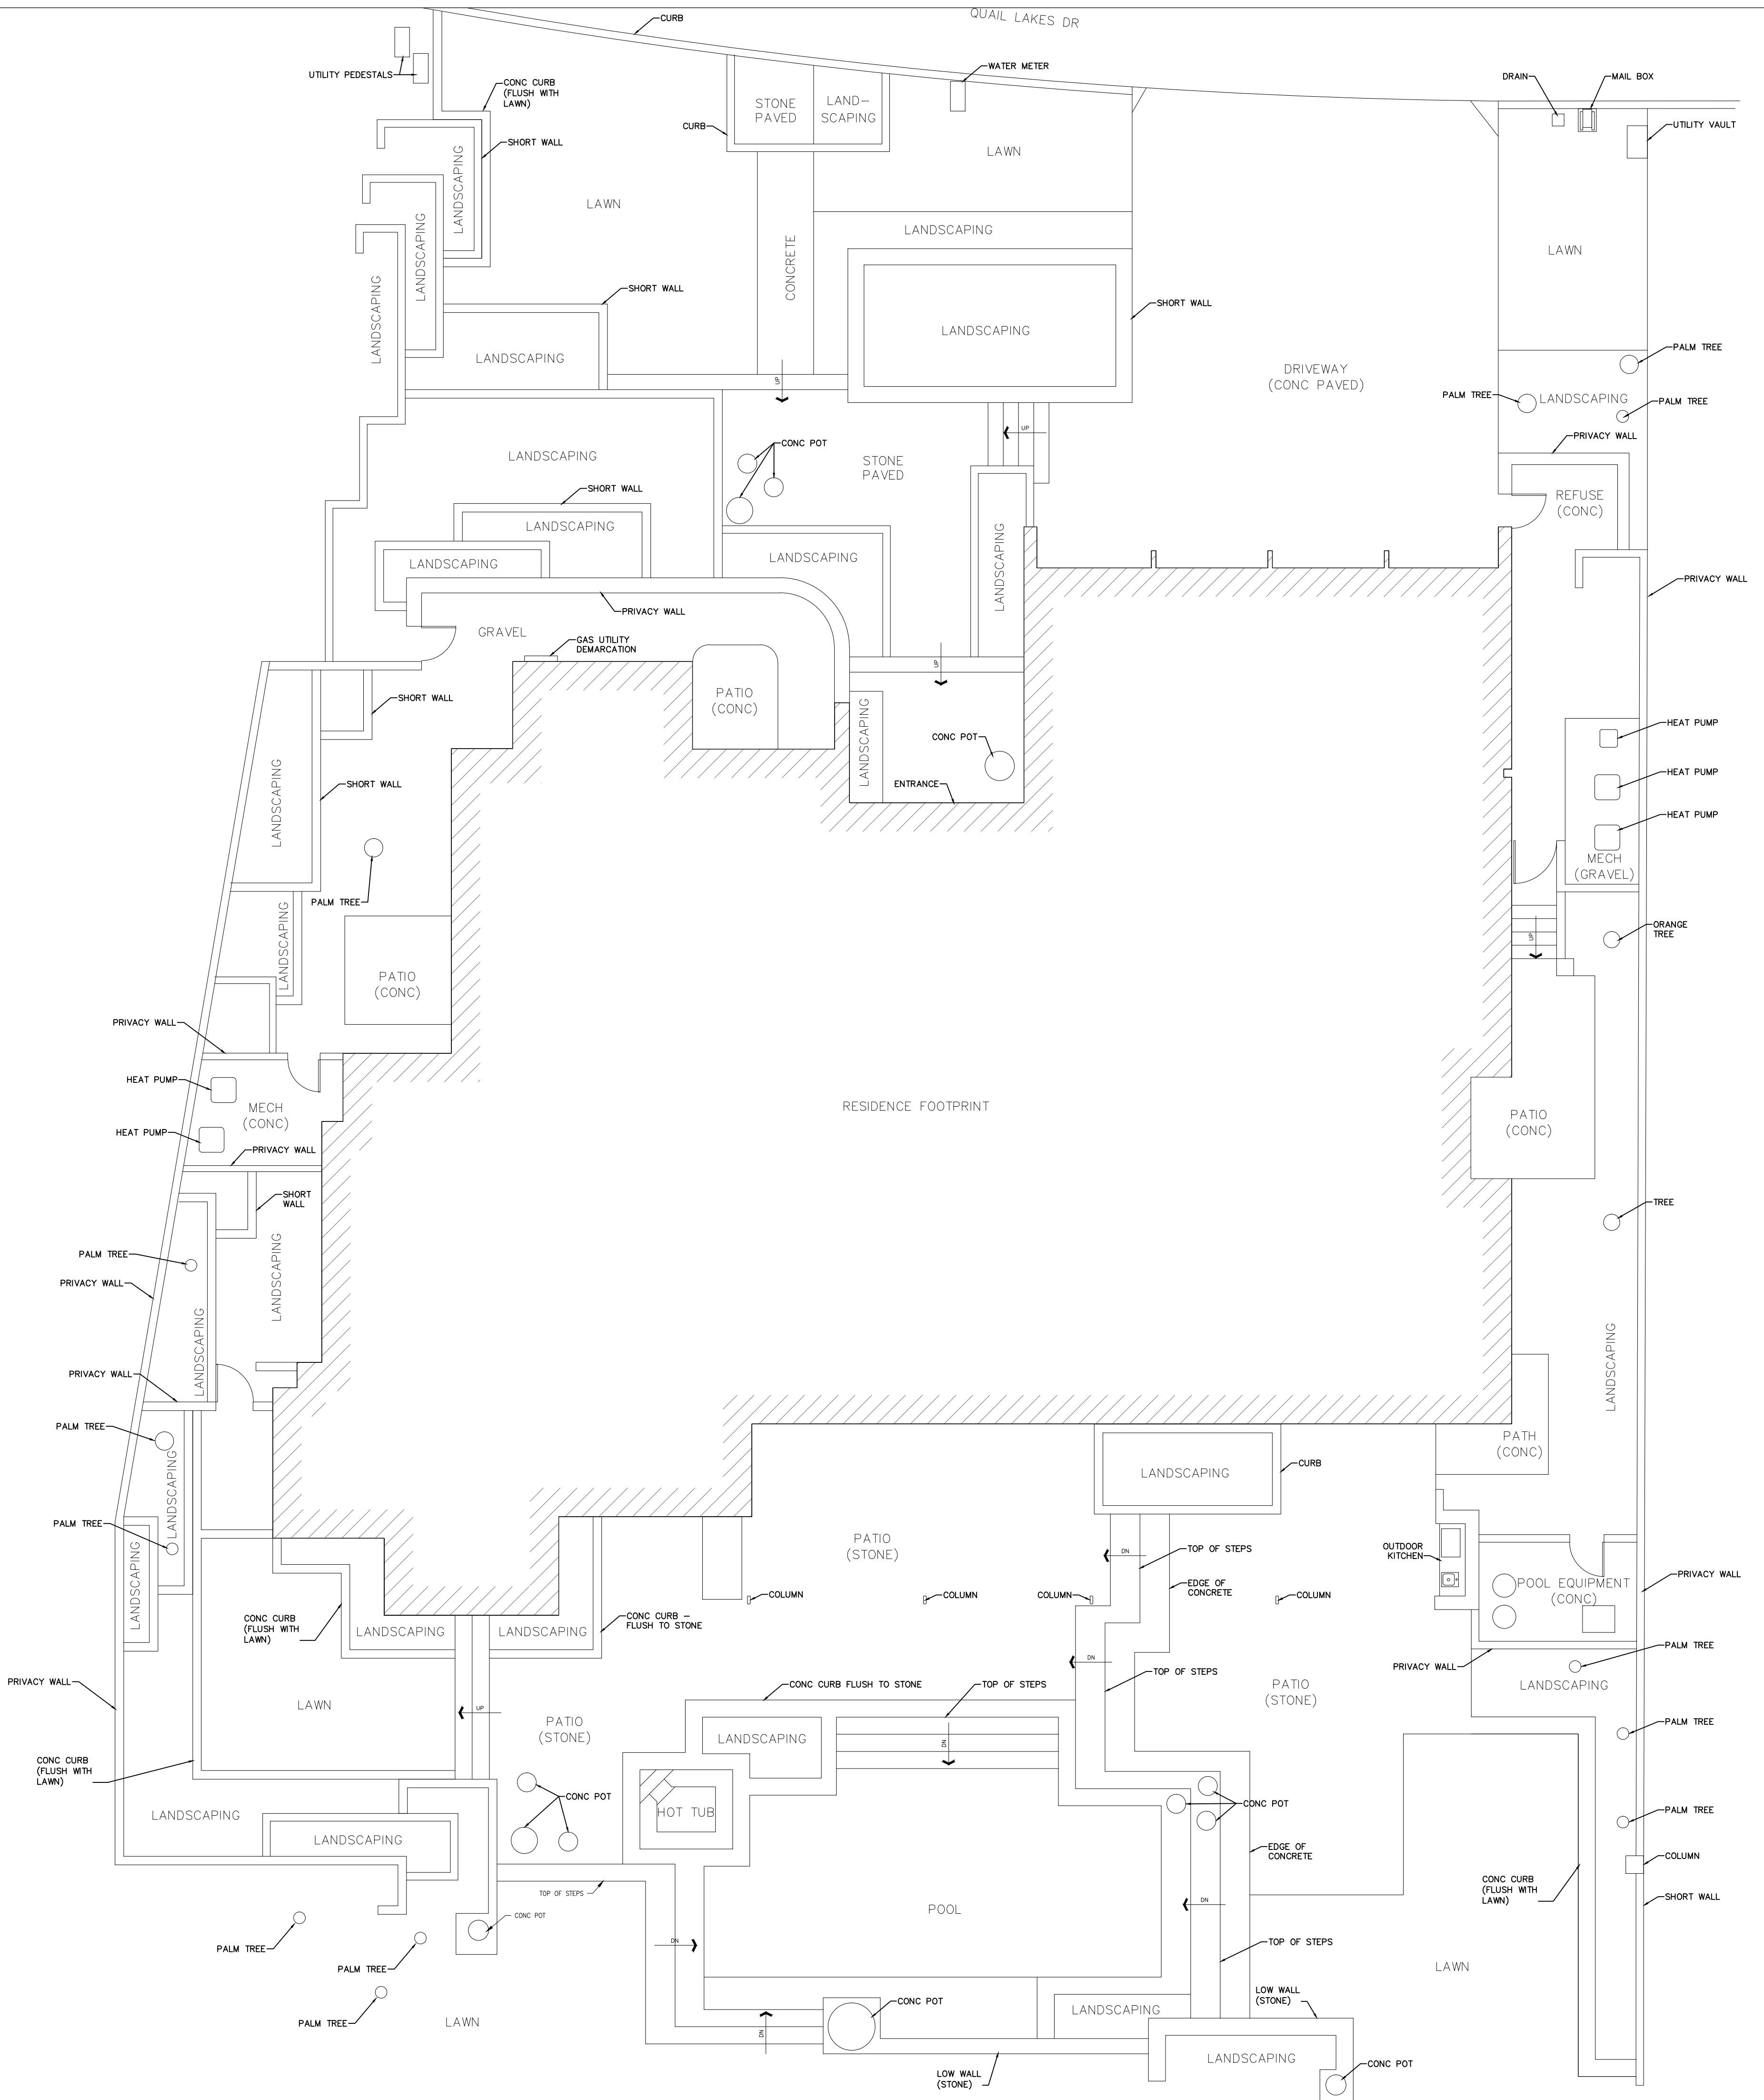

AB-1



02 REVISED TO ADD COVE LIGHT ELEVATIONS 07/08/2019
01 100% SUBMISSION 06/21/2019
NO. ISSUES | REVISIONS DATE

SHEET TITLE

HL PROJECT MANAGER
HL PROJECT DIRECTOR
? PROJECT NUMBER
1/8"=1'-0" SCALE
MM DRAWN BY
SHEET NUMBER

ARCHITECTURAL AS BUILT

FLOORPLAN

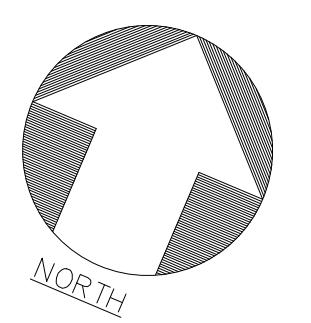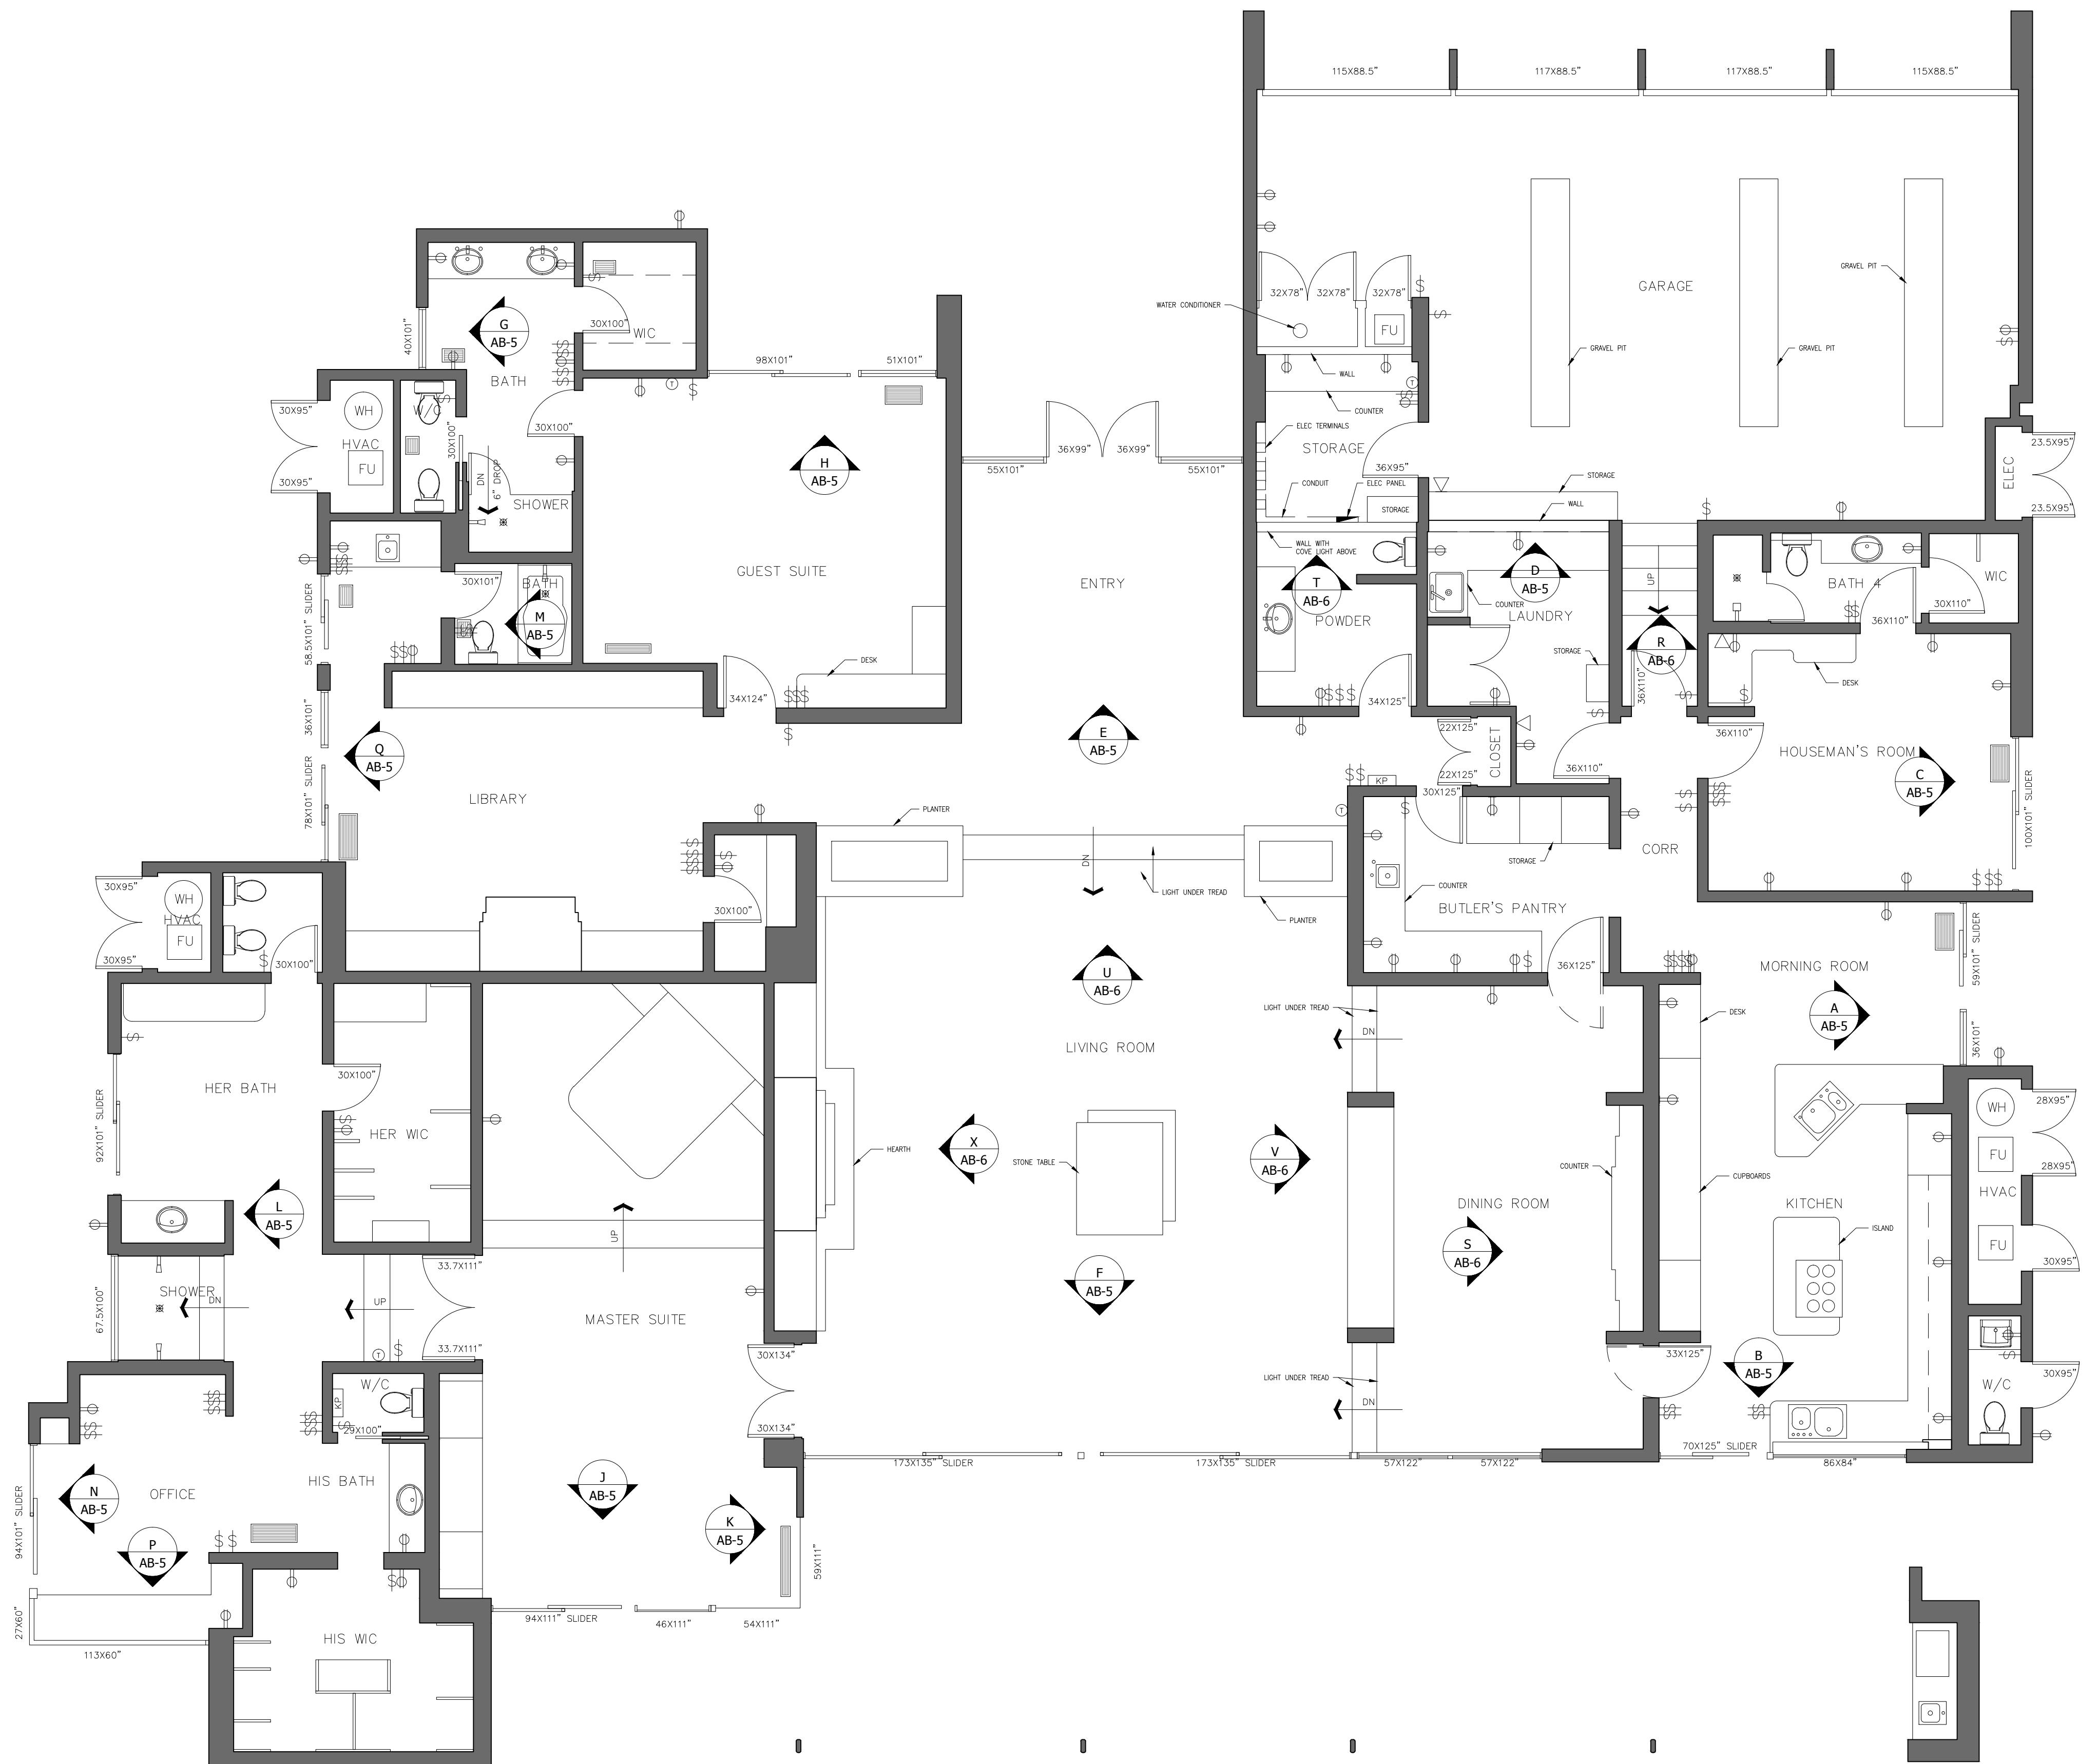

HL	PROJECT MANAGER
HL	PROJECT DIRECTOR
?	PROJECT NUMBER
3/16"=1'-0"	SCALE
MM	DRAWN BY
	SHEET NUMBER

AB-2




© 2017 AEC CONSULTANTS INC

INDIAN WELLS, CA 92210

ARCHITECTURAL AS BUILT

RCP

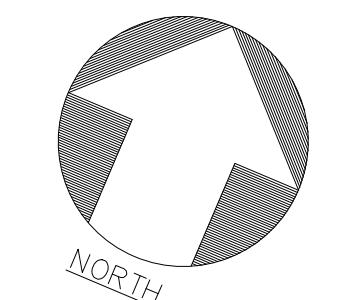

AB-3

HL	PROJECT MANAGER
HL	PROJECT DIRECTOR
?	PROJECT NUMBER
3/16"=1'-0"	SCALE
MM	DRAWN BY
	SHEET NUMBER





© 2017 AEC CONSULTANTS INC

INDIAN WELLS, CA 92210

ARCHITECTURAL AS BUILT


ROOF PLAN

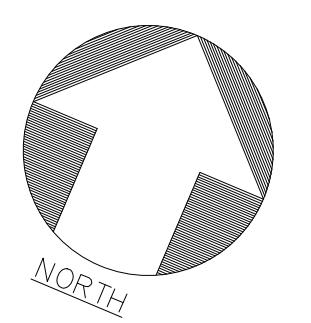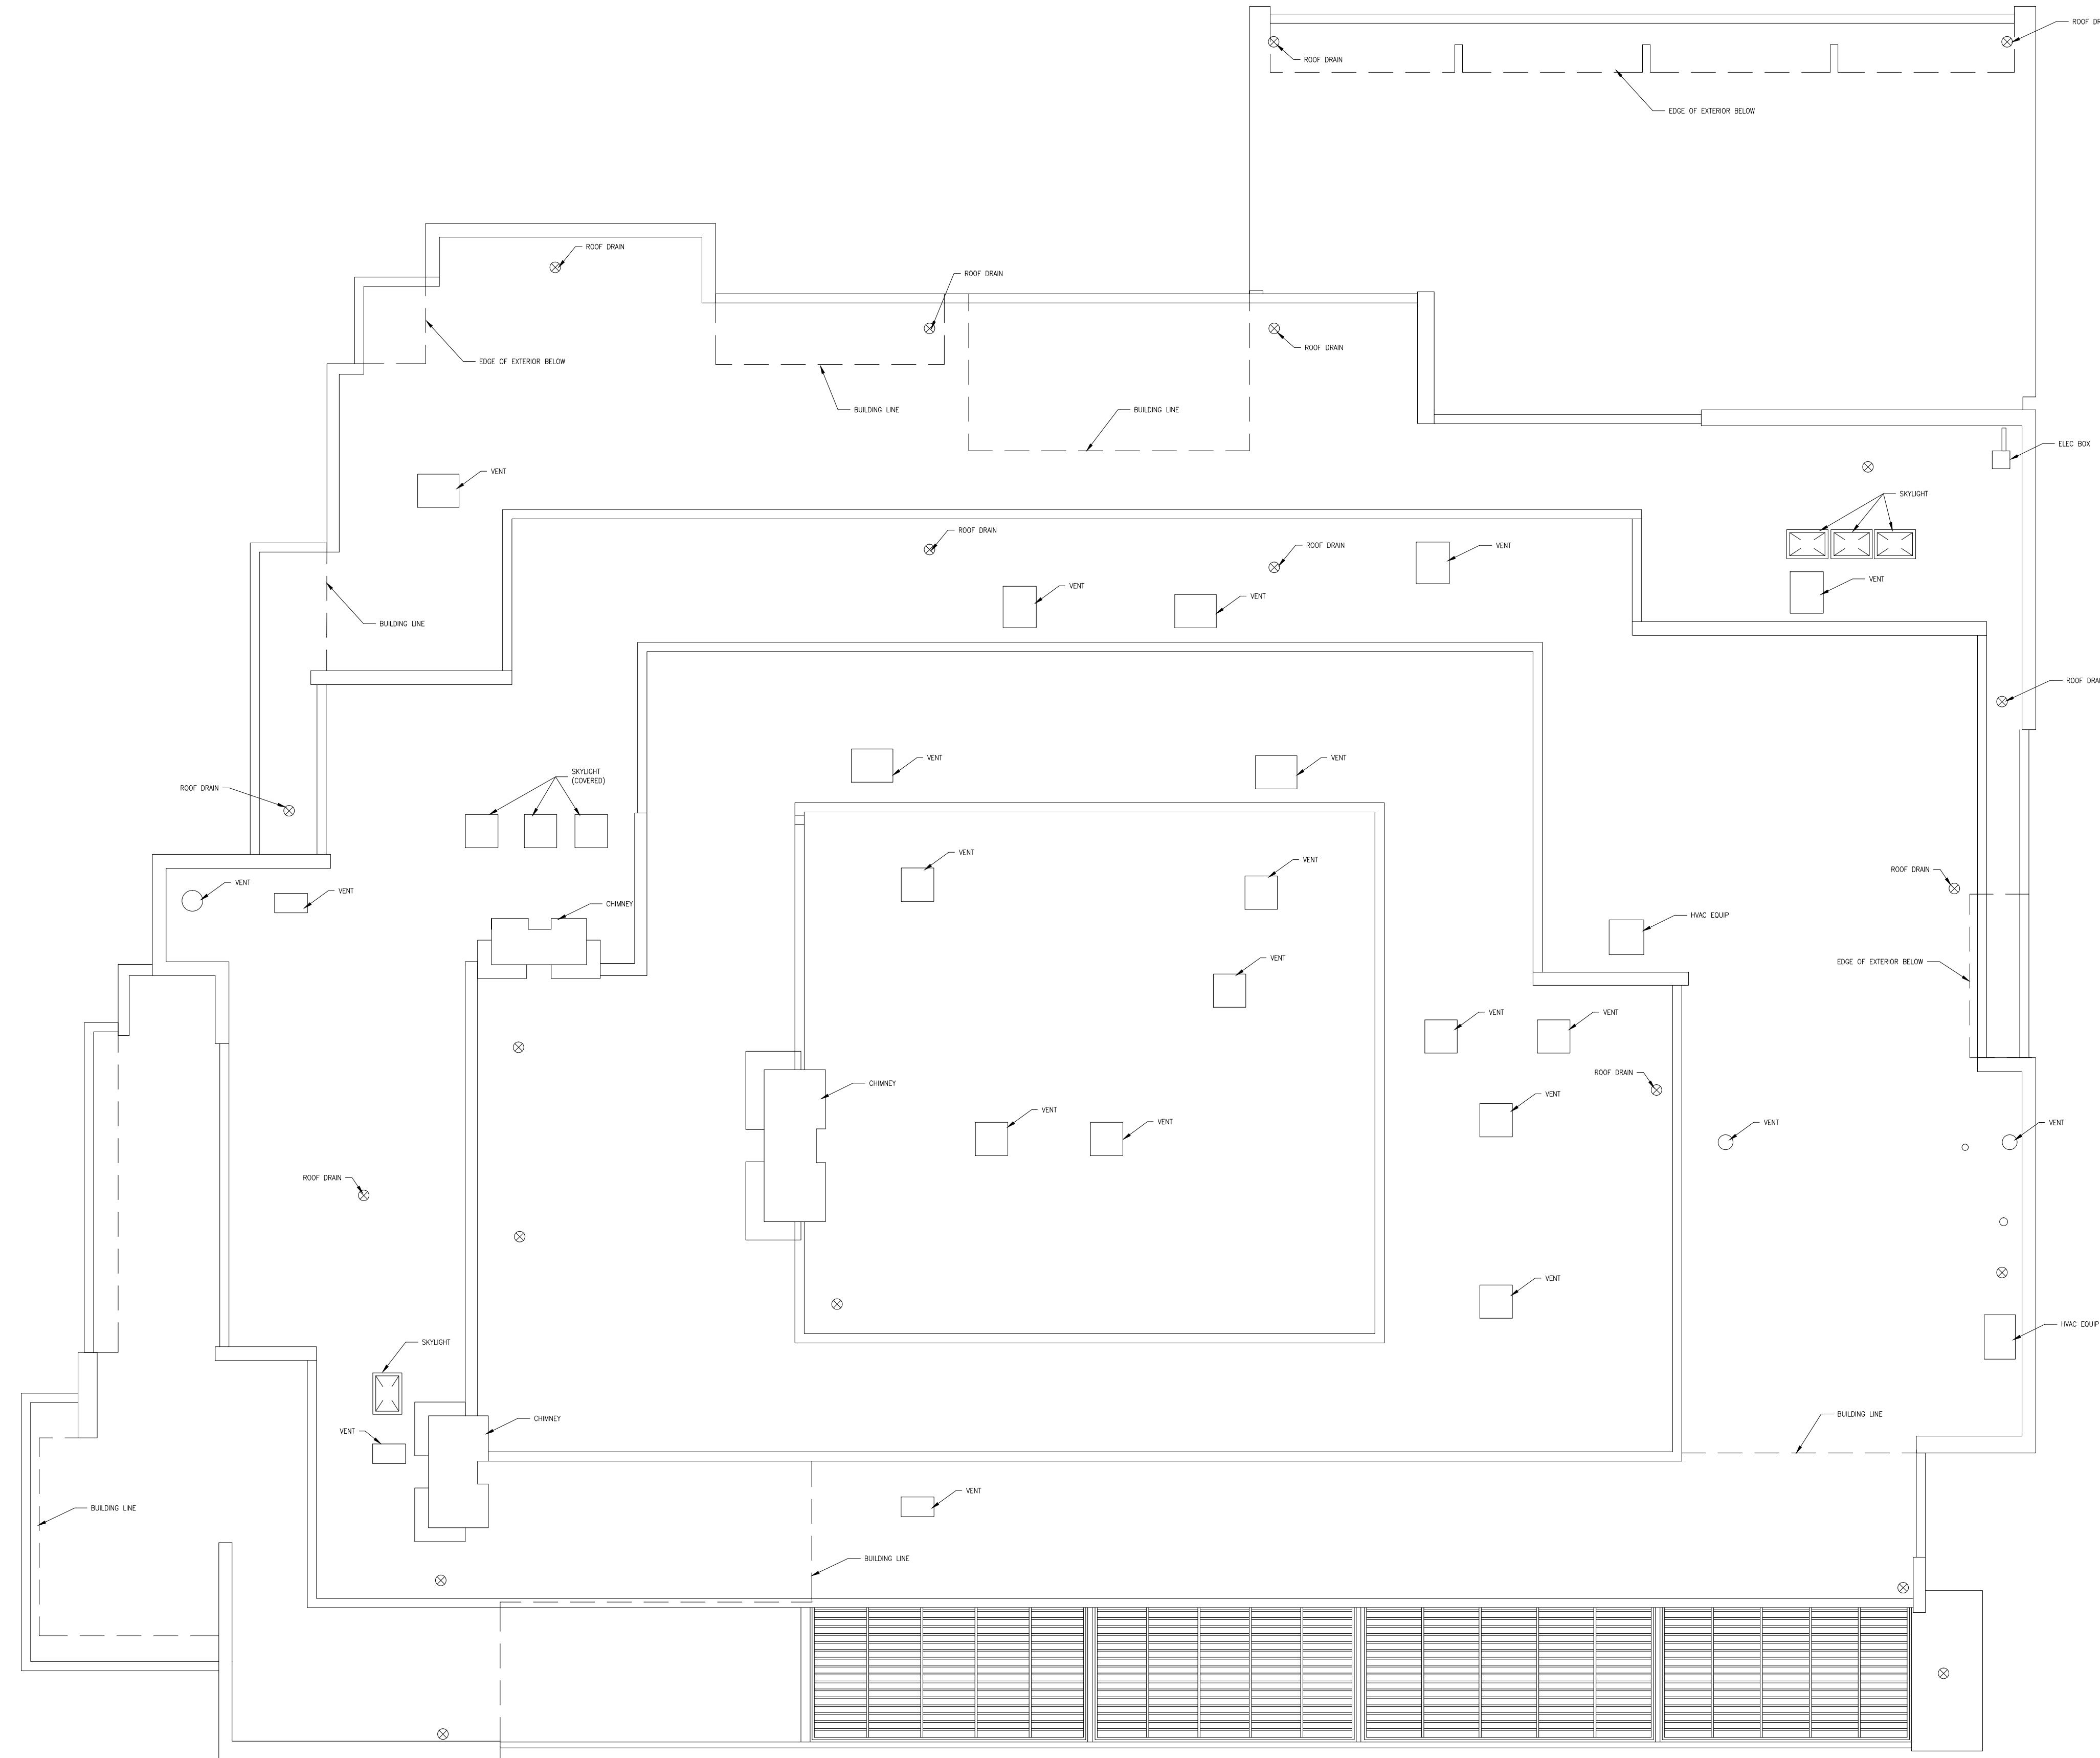


HL	PROJECT MANAGER
HL	PROJECT DIRECTOR
?	PROJECT NUMBER
3/16"=1'-0"	SCALE
MM	DRAWN BY
	SHEET NUMBER

AB-4


INDIAN WELLS, CA 92210

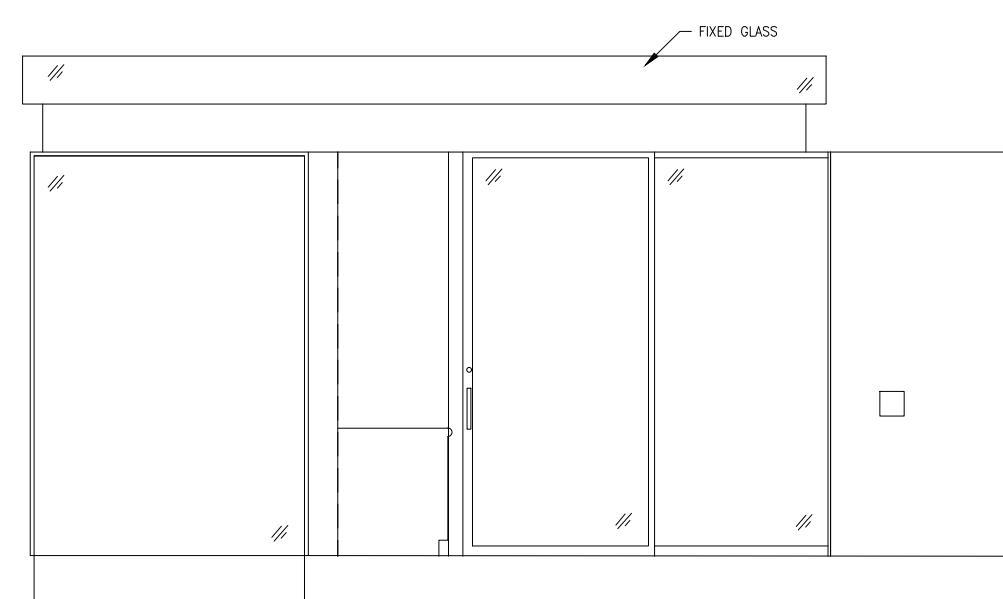


INTERIOR ELEVATION L

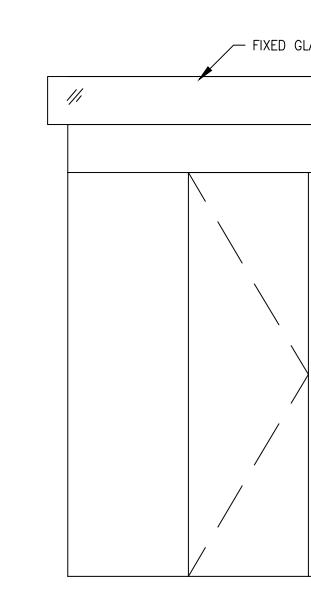


INTERIOR ELEVATION M

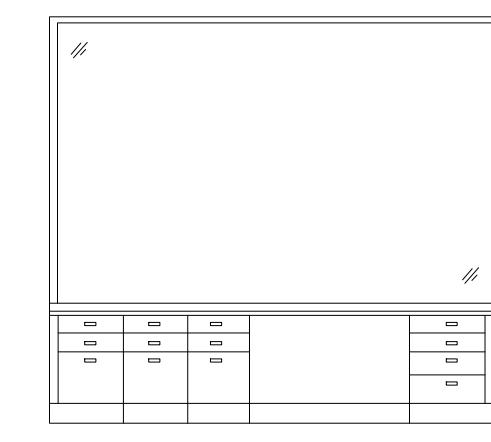


INTERIOR ELEVATION N

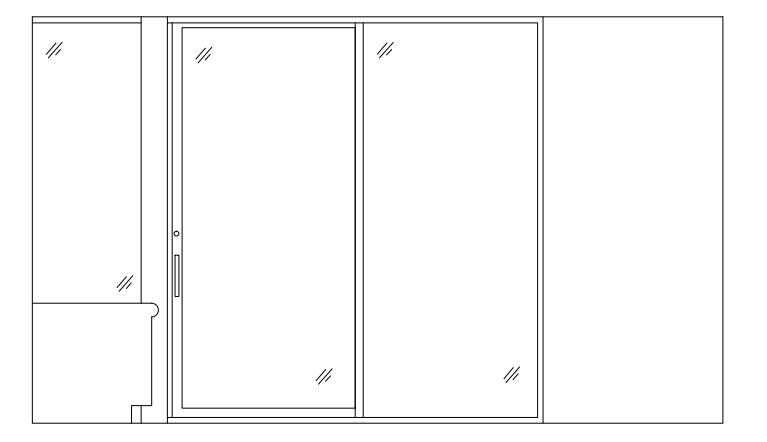


INTERIOR ELEVATION P

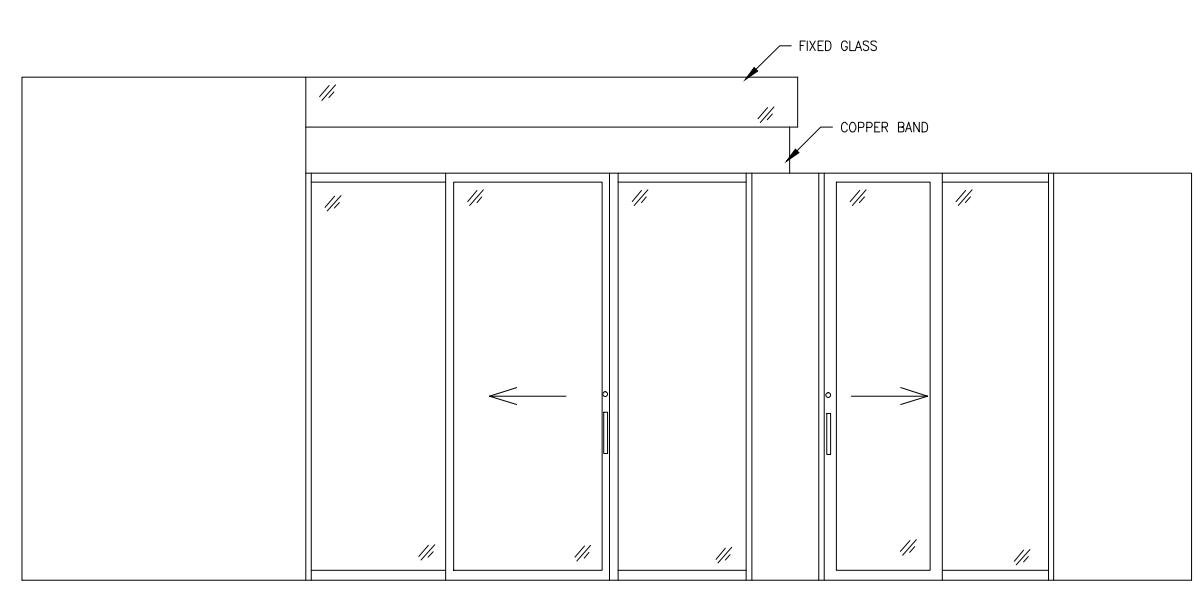


INTERIOR ELEVATION Q

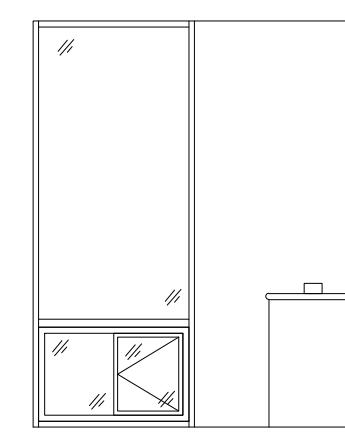


INTERIOR ELEVATION G

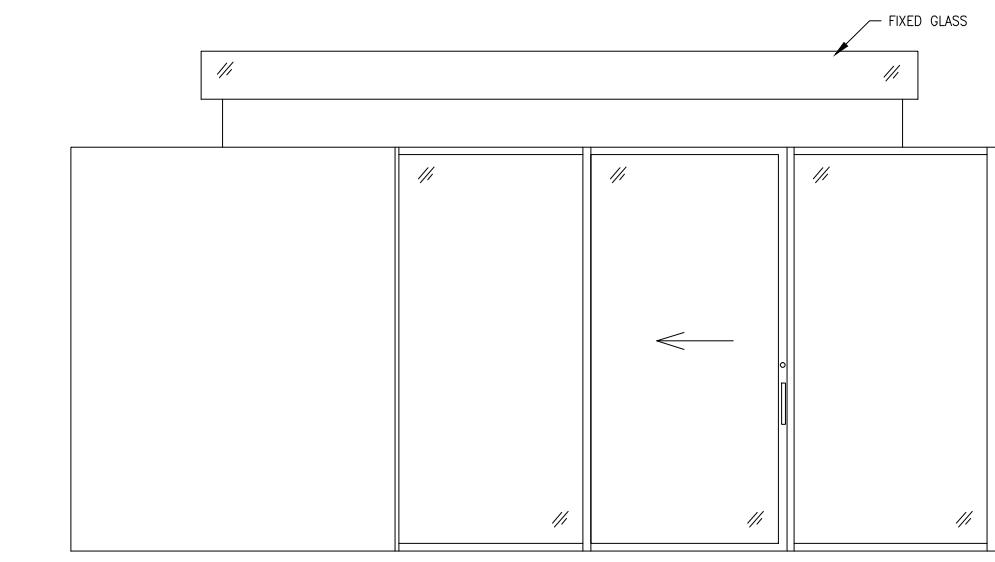


INTERIOR ELEVATION H

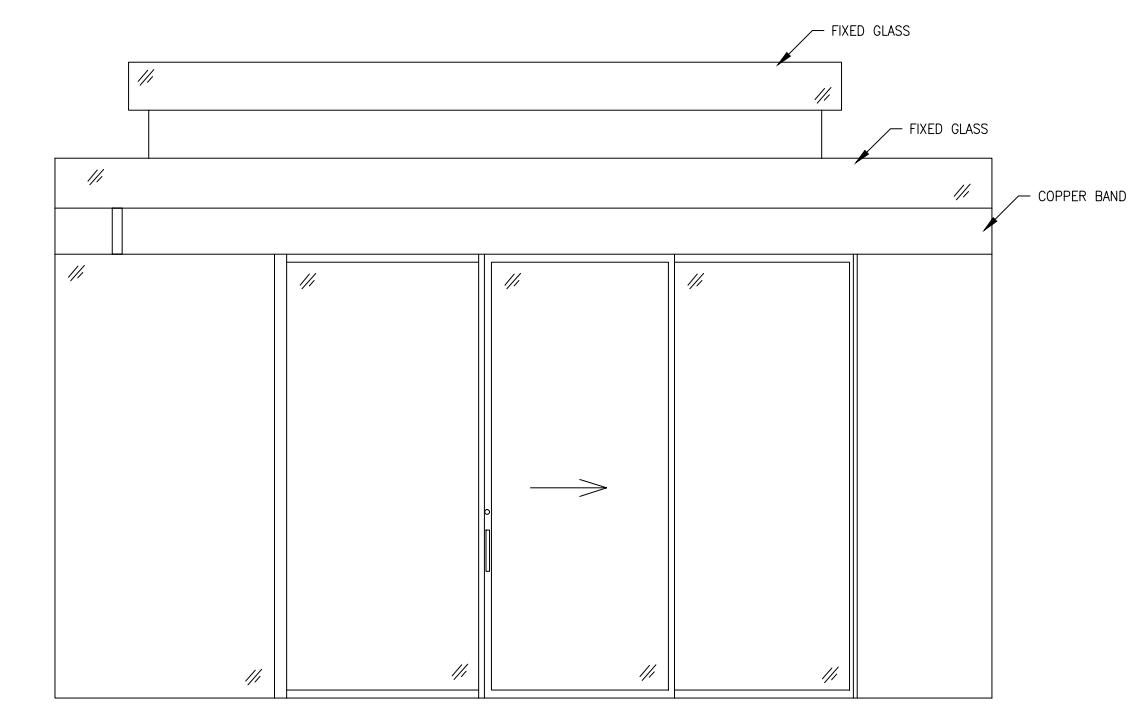


INTERIOR ELEVATION J

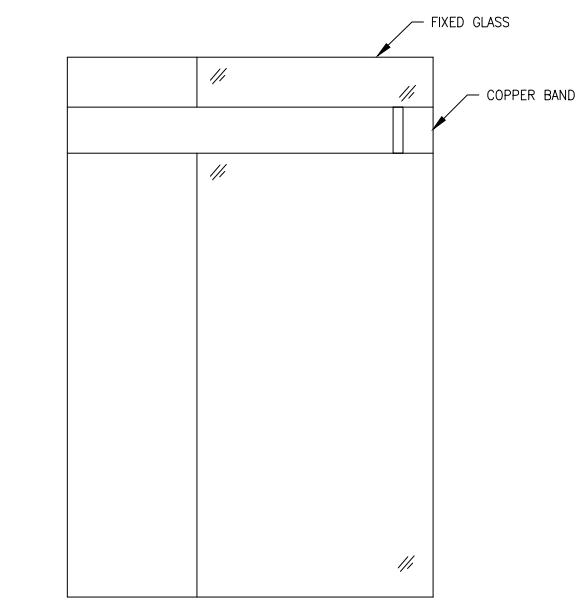


INTERIOR ELEVATION K

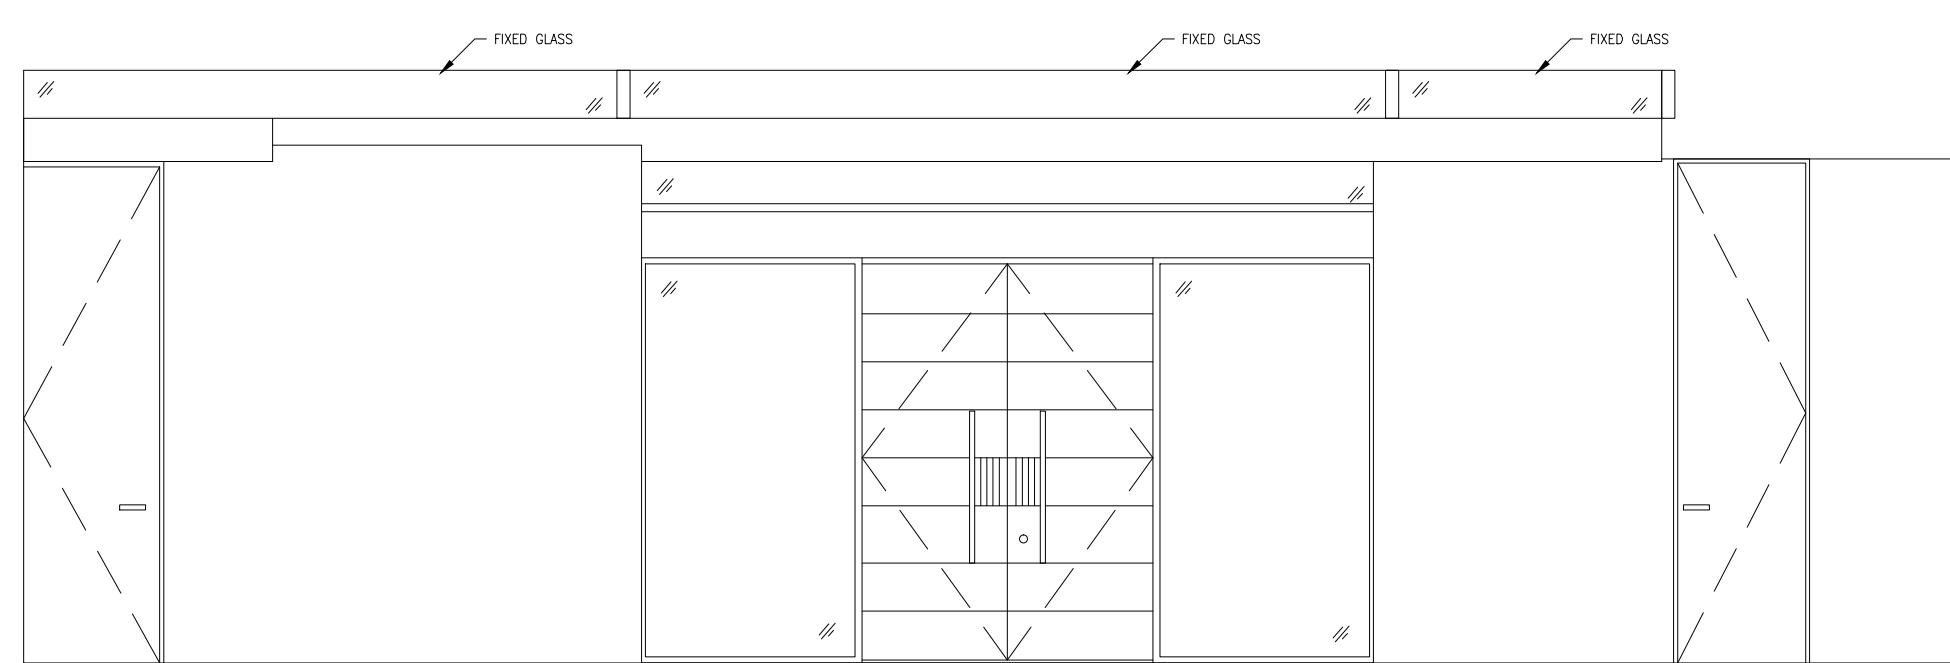


INTERIOR ELEVATION E

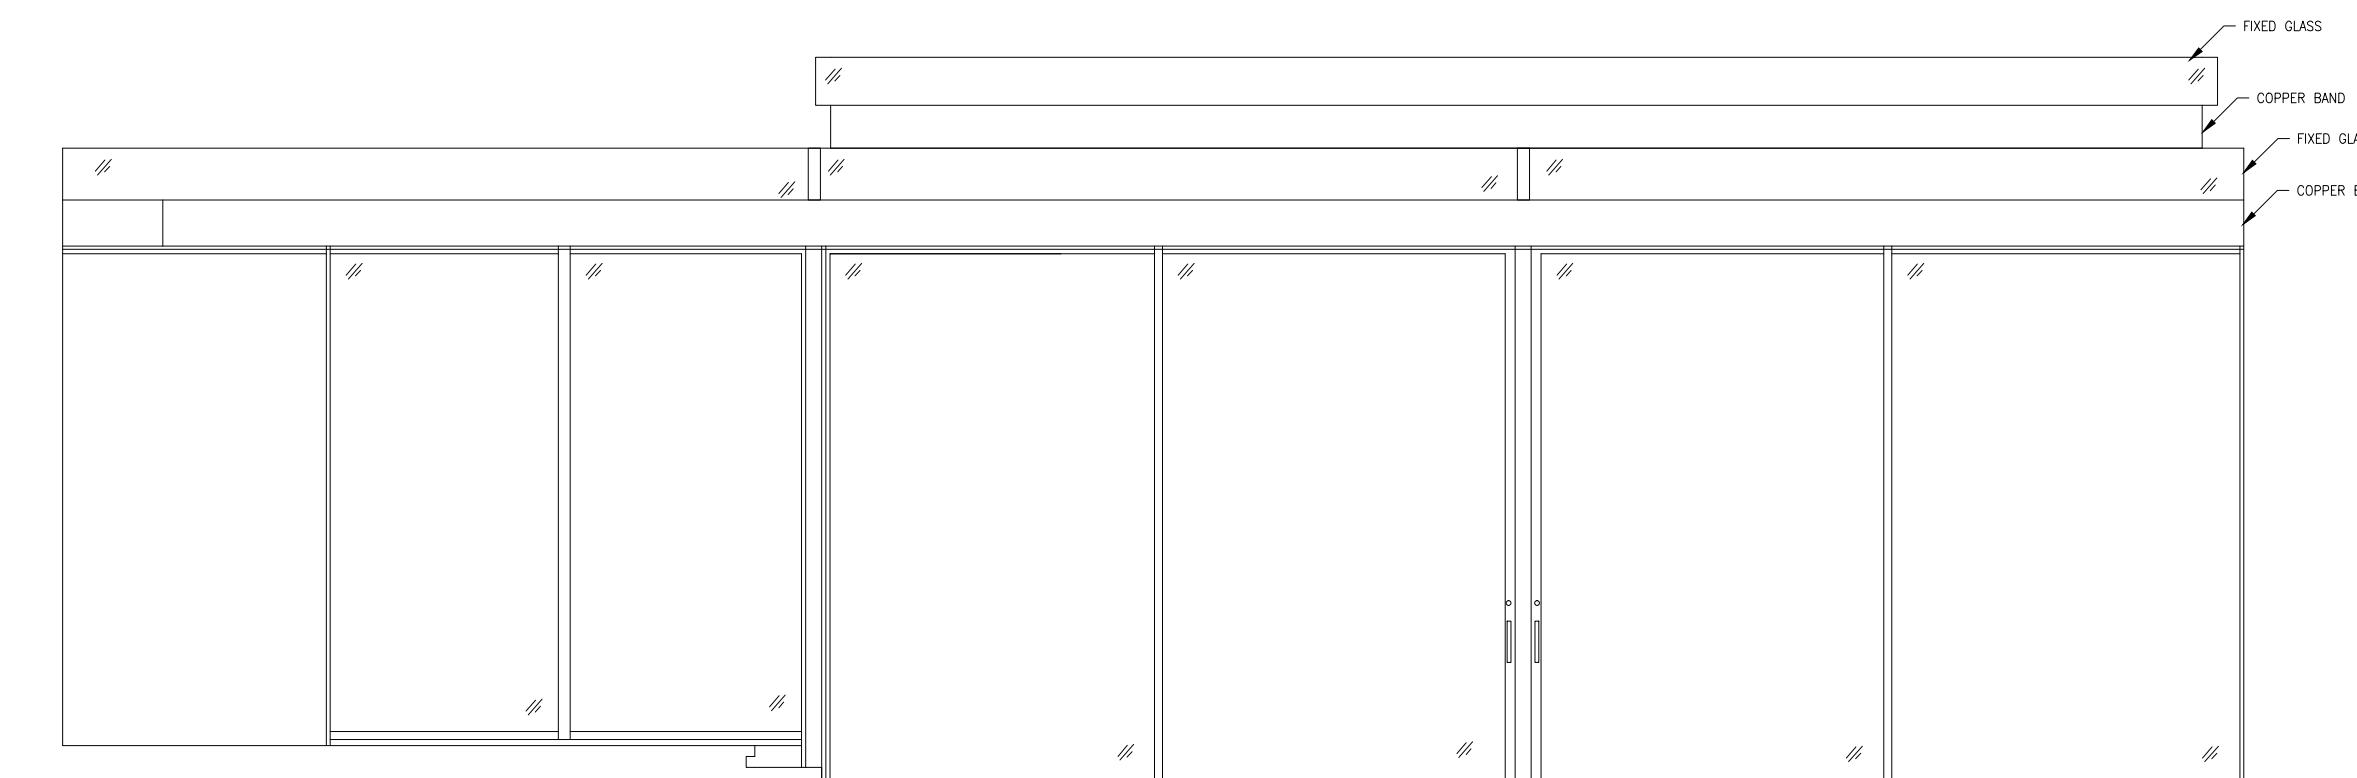


INTERIOR ELEVATION F

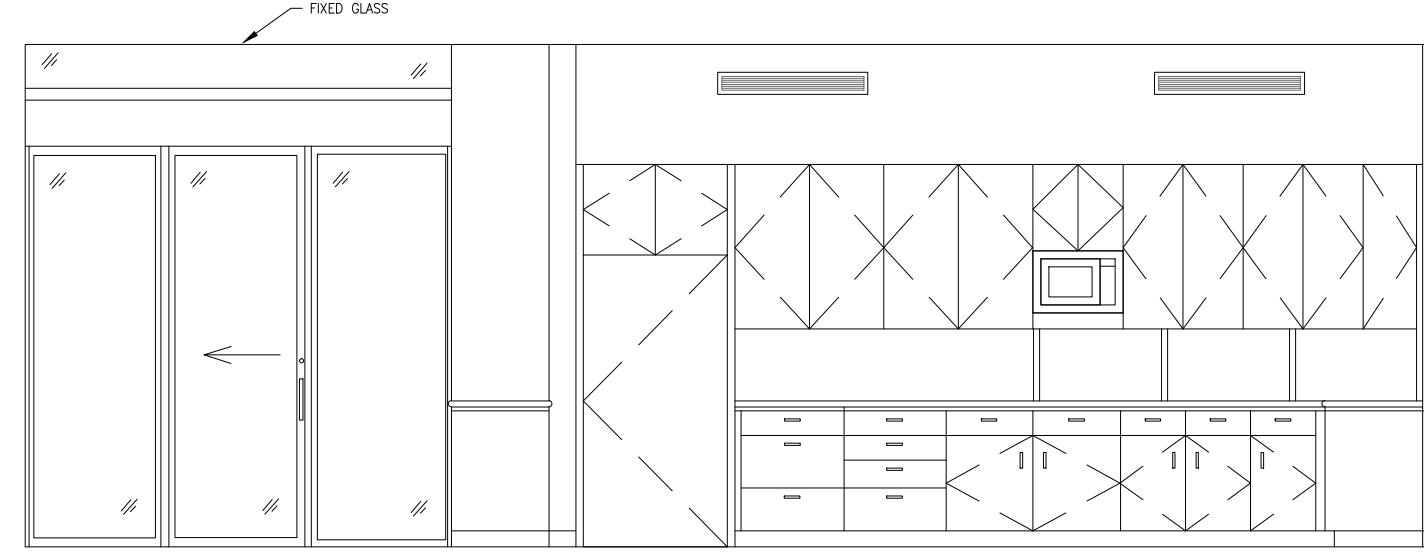


INTERIOR ELEVATION A

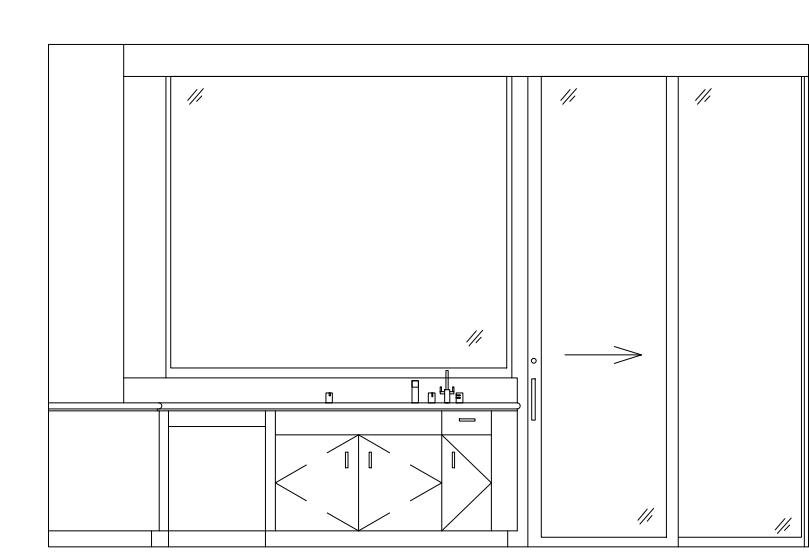

INTERIOR ELEVATION B

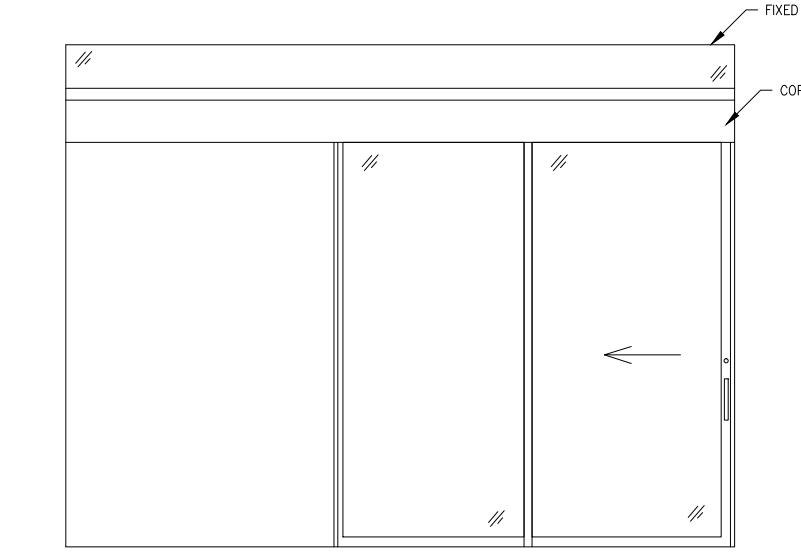

INTERIOR ELEVATION C

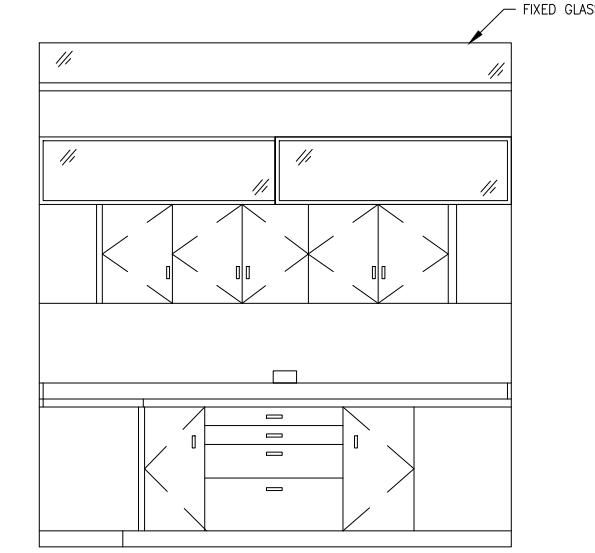

INTERIOR ELEVATION D

ARCHITECTURAL AS BUILT

02 _____
01 _____
NO. ISSUES | REVISIONS DATE
SHEET TITLE

ELEVATIONS


HL	PROJECT MANAGER
HL	PROJECT DIRECTOR
?	PROJECT NUMBER
1/4"=1'-0"	SCALE
MM	DRAWN BY
	SHEET NUMBER

AB-5




ARCHITECTURAL AS BUILT


INDIAN WELLS, CA 92210

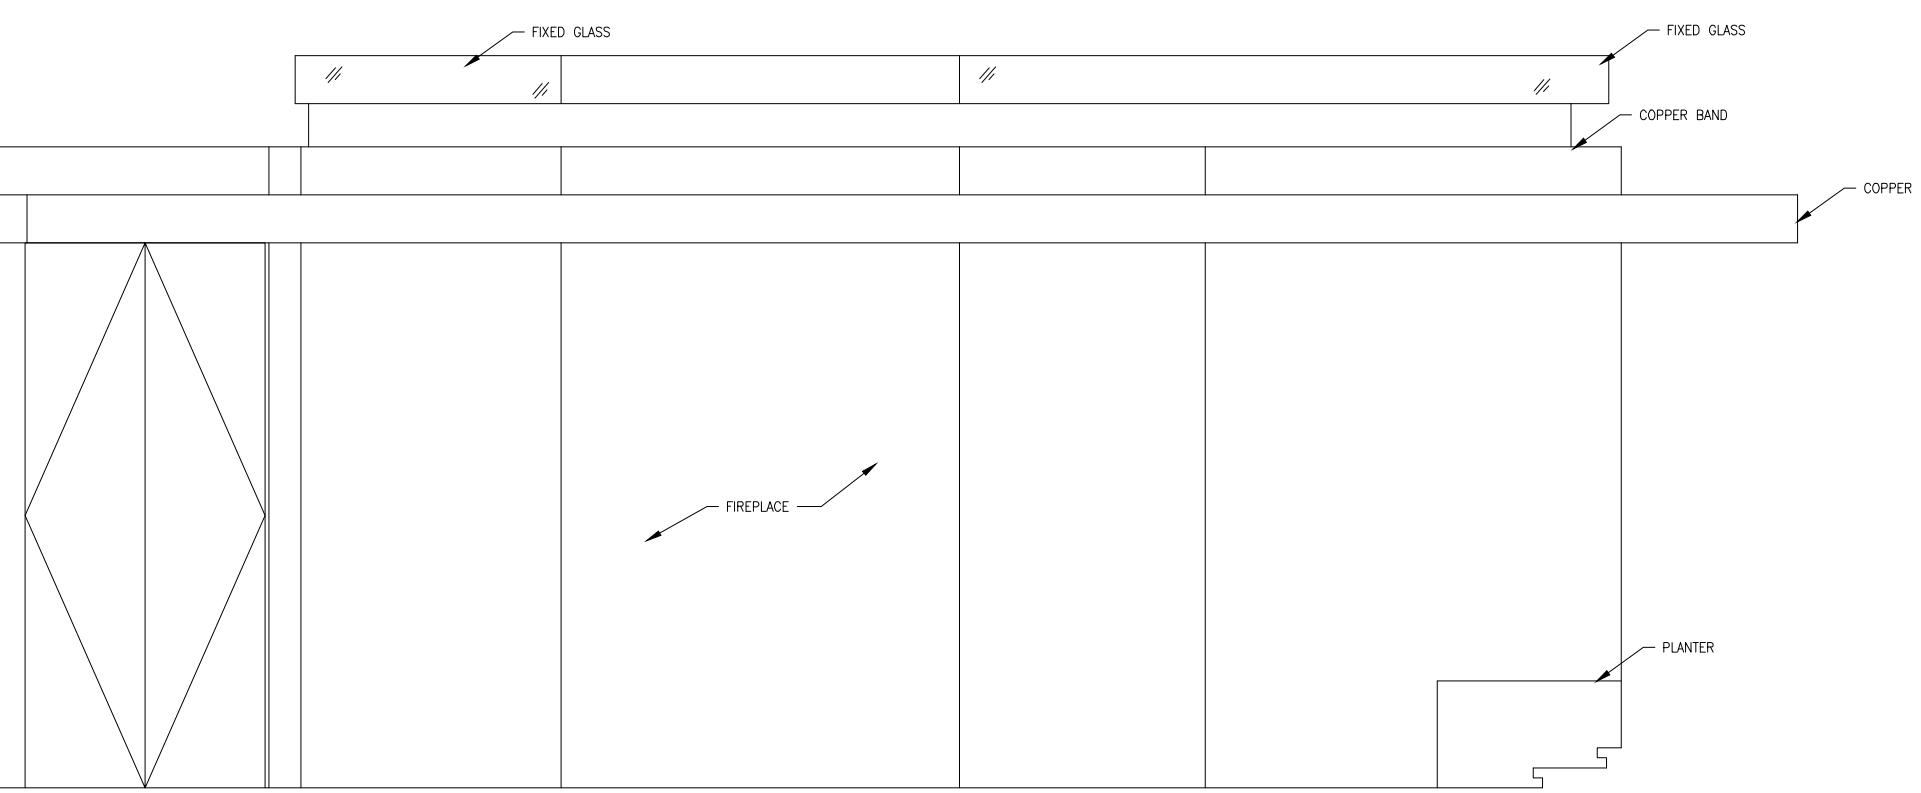


INTERIOR ELEVATION X

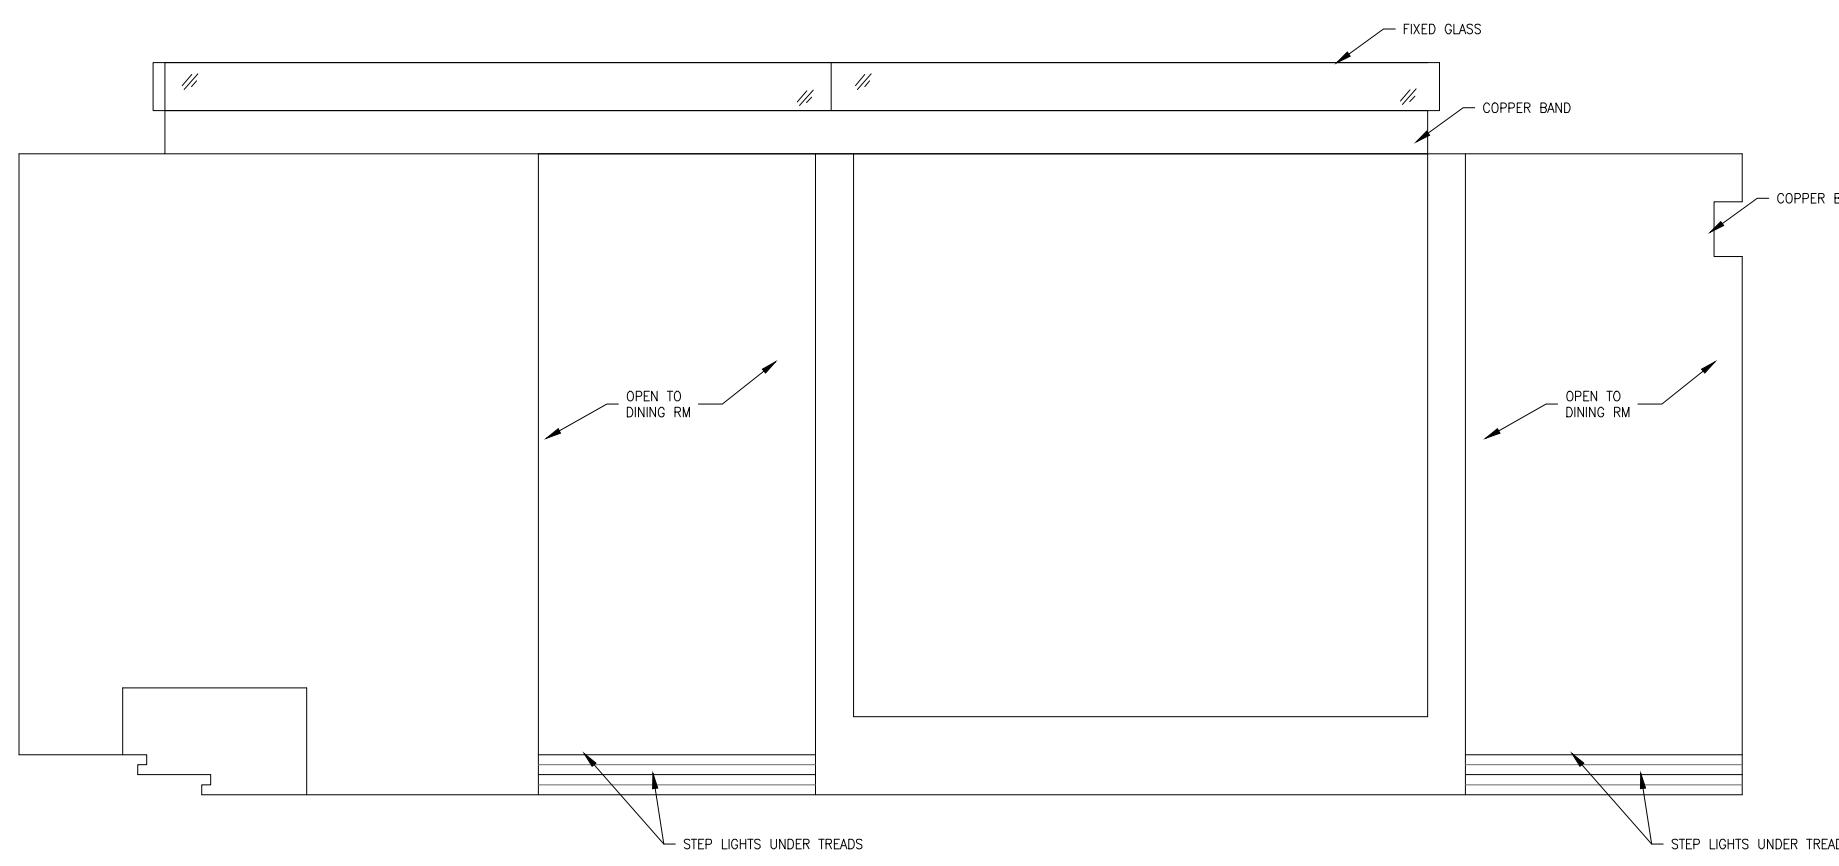


INTERIOR ELEVATION V

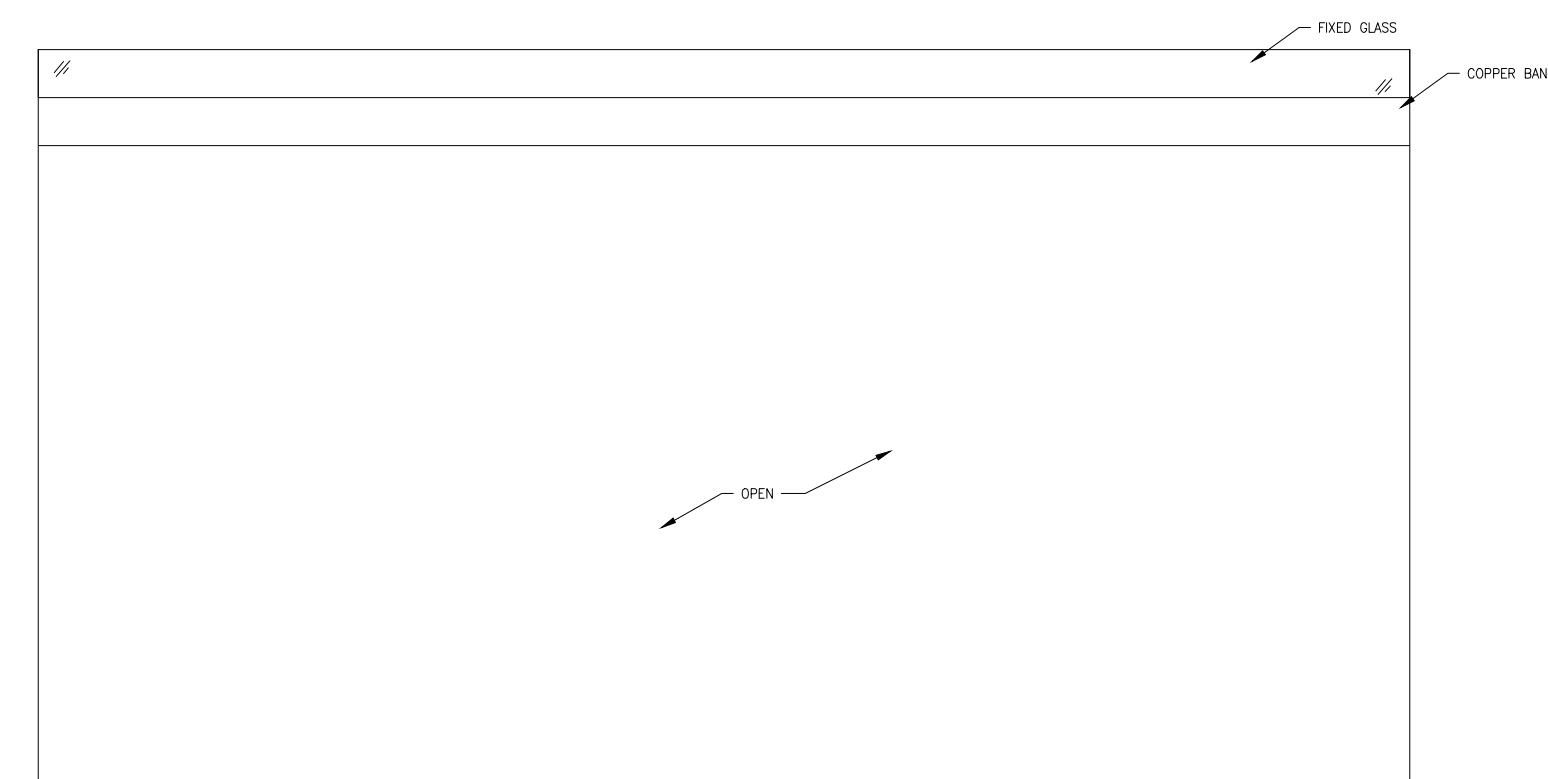


INTERIOR ELEVATION W

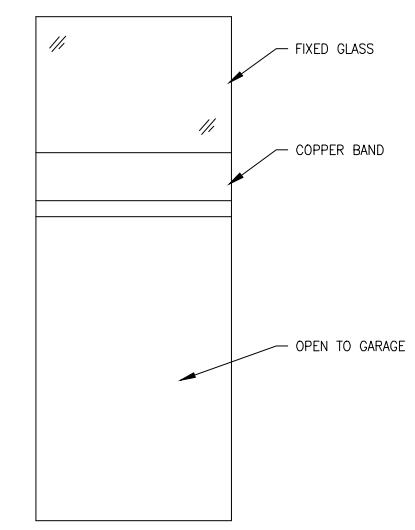


INTERIOR ELEVATION R

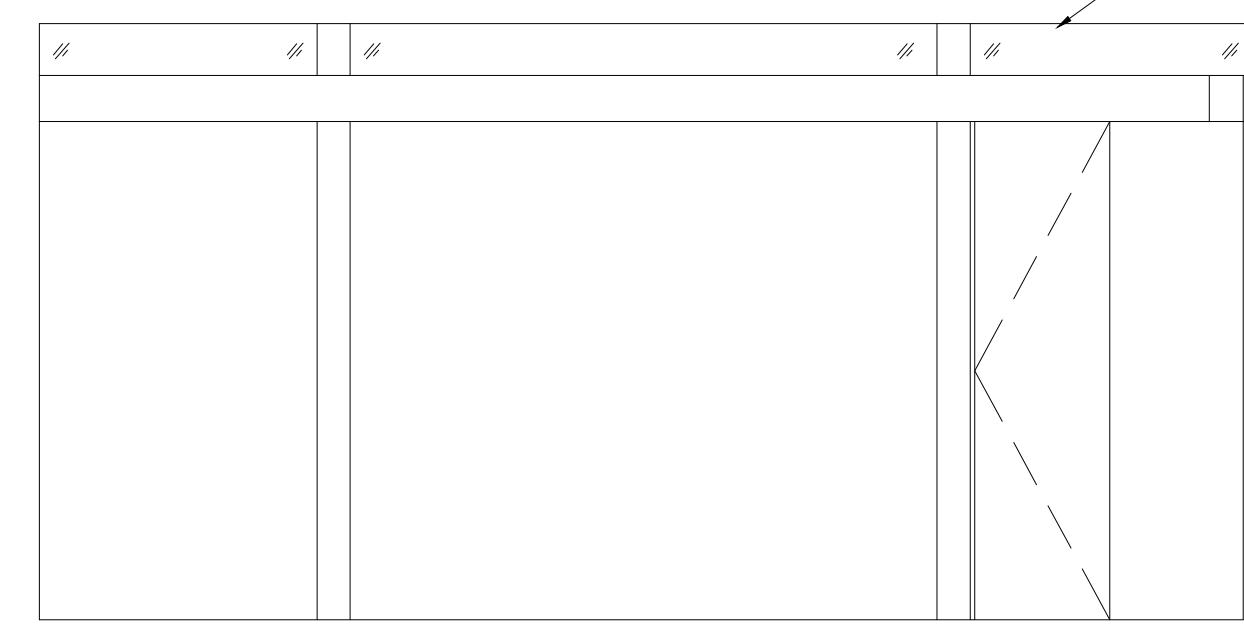

INTERIOR ELEVATION S

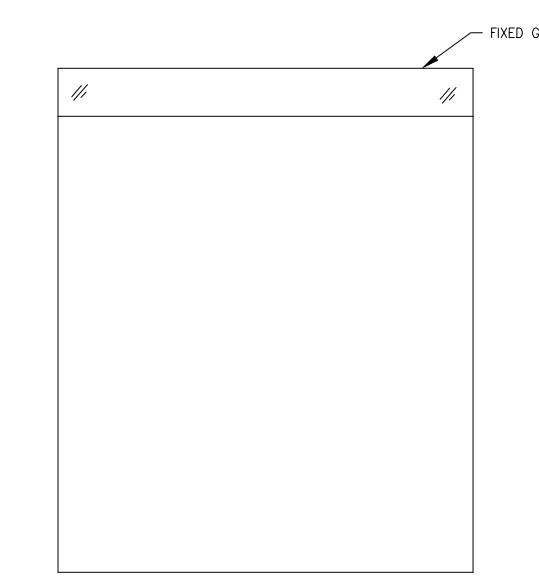

INTERIOR ELEVATION T

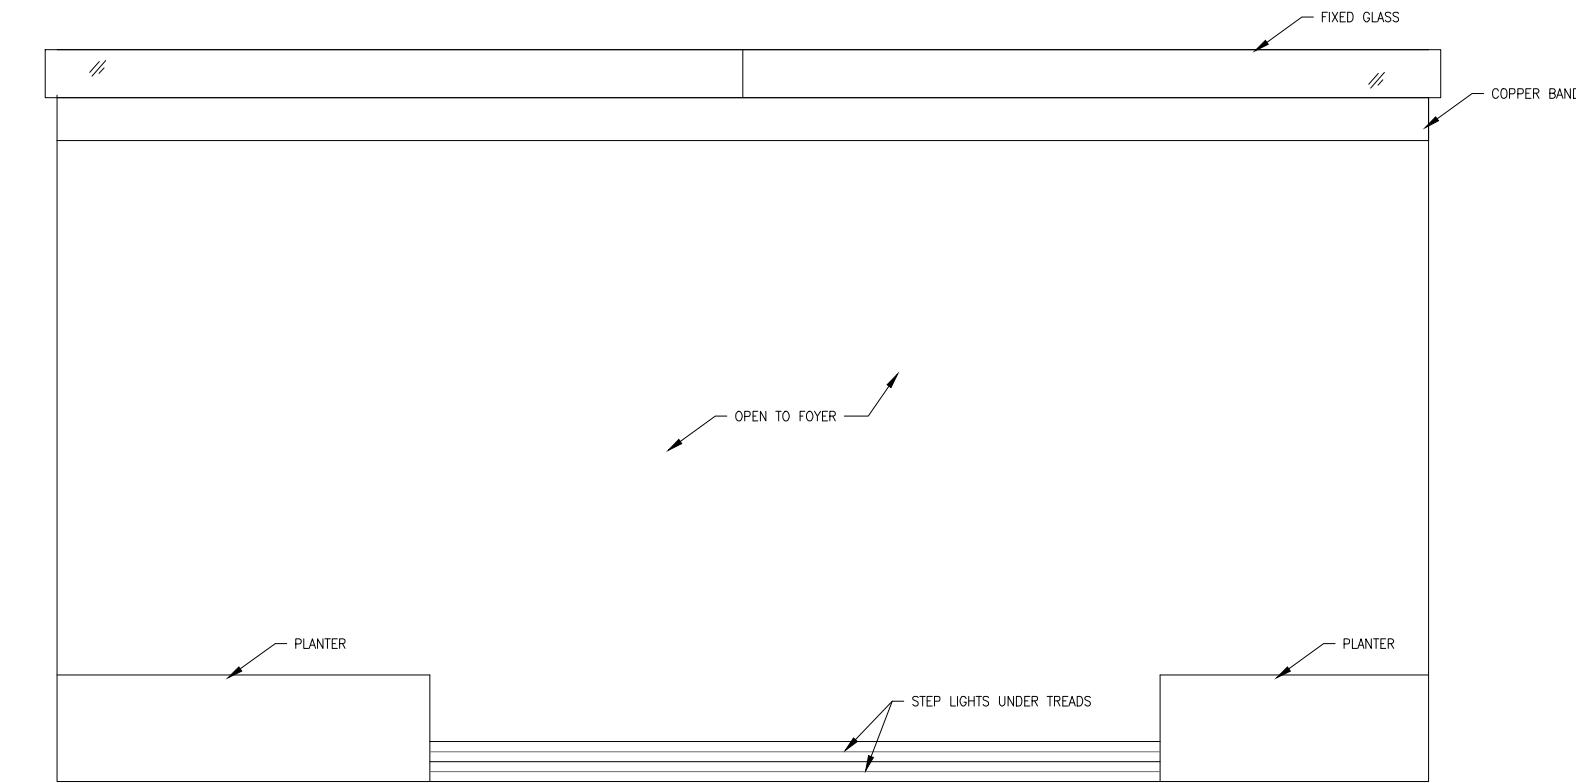

INTERIOR ELEVATION U

HL	PROJECT MANAGER
HL	PROJECT DIRECTOR
?	PROJECT NUMBER
1/4"=1'-0"	SCALE
MM	DRAWN BY
	SHEET NUMBER

ELEVATIONS

02
01
NO. ISSUES | REVISIONS DATE
SHEET TITLE

AB-6