 
 
 
 
 
 
 
 
 
 
 
 
 
 
 
 
 
 
 


SYMBOLS LEGEND

RCP

 
 
 
 
 
 
-  EXHAUST VENT
-  CEILING MOUNTED LIGHT FIXTURE
-  CEILING MOUNTED DIRECTIONAL LIGHT
-  RECESSED CAN LIGHT
-  EYEBALL OR SMALL CAN LIGHT
-  PENDANT LIGHT
-  INDIVIDUAL FLUOR. LAY-IN FIXTURE 4 BULB
-  INDIVIDUAL FLUOR. HANGING FIXTURE 2 BULB
-  INDIVIDUAL FLUOR. FLUSH MOUNT FIXTURE 4 BULB
-  CAMERA
-  BLANK CEILING PLATE MOTION DET.
-  WALL MOUNT VENT
-  SUPPLY VENT
-  SUPPLY VENT
-  RETURN VENT
-  RETURN VENT
-  SPEAKER

-  TRACK LIGHT OR VANITY LIGHT
-  WALL-MOUNTED LIGHT FIXTURE
-  EMERGENCY EXIT SIGN
-  EMERGENCY EXIT LIGHT
-  EMERGENCY EXIT LIGHT W/ SIGN
-  LIGHTED STAIR SIGN
-  FLOOD LIGHT
-  PHOTO CELL
-  CEILING FAN
-  CEILING FAN W/ LIGHT KIT
-  JUNCTION BOX



7-2-6 CEILING HEIGHT AND TRIM 7'-2" ABOVE FLOOR BELOW WITH 6" CROWN MOULDING. NOTE: ALL CEILINGS NOT LABELED ARE PLASTER. CEILINGS SHOWN WITH A GRID ARE LAY IN ACOUSTICAL TILE..

JUNCTION BOX


ELECTRIC

-  DATA OUTLET
-  TELEPHONE JACK
-  ELECTRIC SWITCH
-  CABLE TELEVISION OUTLET
-  BLANK PLATE
-  FLOOR OUTLET
-  DUPLEX RECEPTACLE OUTLET
-  SPECIAL PURPOSE CONNECTION OR OUTLET
-  QUADRUPLX RECEPTACLE OUTLET
-  CEILING RECEPTACLE OUTLET
-  ELECTRIC PANEL
-  ELECTRIC METER
-  MOTION SENSOR
-  BUTTON SWITCH
-  DISCONNECT SWITCH
-  WALL MOUNT EXHAUST VENT
-  GROUND/FLOOR LIGHT
-  BASEBOARD HEAT
-  KEY PAD


 
 
FIRE PROTECTION

-  FIRE EXTINGUISHER
-  FIRE PULL
-  FIRE ALARM (HORN/SRTOBE)
-  SMOKE DETECTOR
-  SMOKE ALARM SPEAKER
-  SPRINKLER HEAD CEILING MOUNT
-  SPRINKLER HEAD WALL MOUNT

 MEP


-  THERMOSTAT
-  FLOOR DRAIN
-  VALVE
-  HOSE BIB
-  WATER SUPPLY
-  SUSPENDED GAS HEATER

   MISC


-  CABINET SCHEDULE LABEL
-  WINDOW SCHEDULE LABEL
-  BOLLARD
-  11-4-11/16 SPOT ELEVATION

7-2-6


CEILING HEIGHT AND TRIM 7'-2" ABOVE FLOOR BELOW WITH 6" CROWN MOULDING. NOTE: ALL CEILINGS NOT LABELED ARE PLASTER. CEILINGS SHOWN WITH A GRID ARE LAY IN ACOUSTICAL TILE..

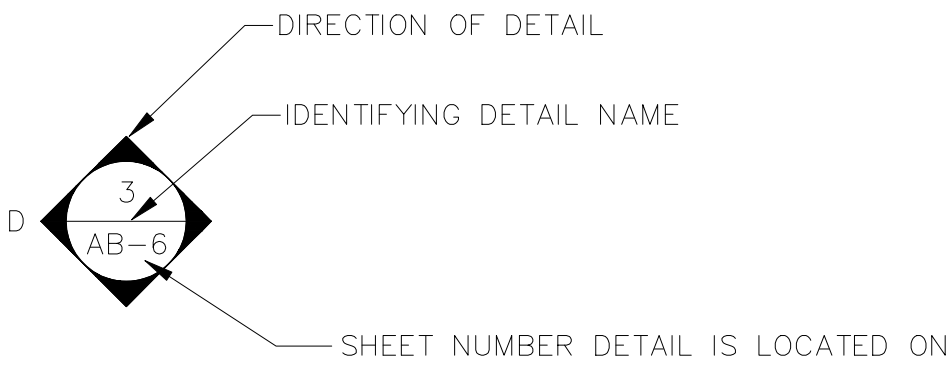

INTERIOR ELEVATIONS

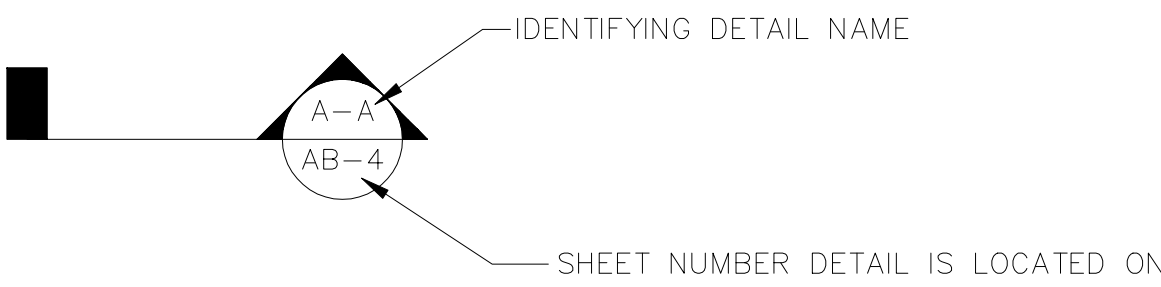

BUILDING SECTIONS

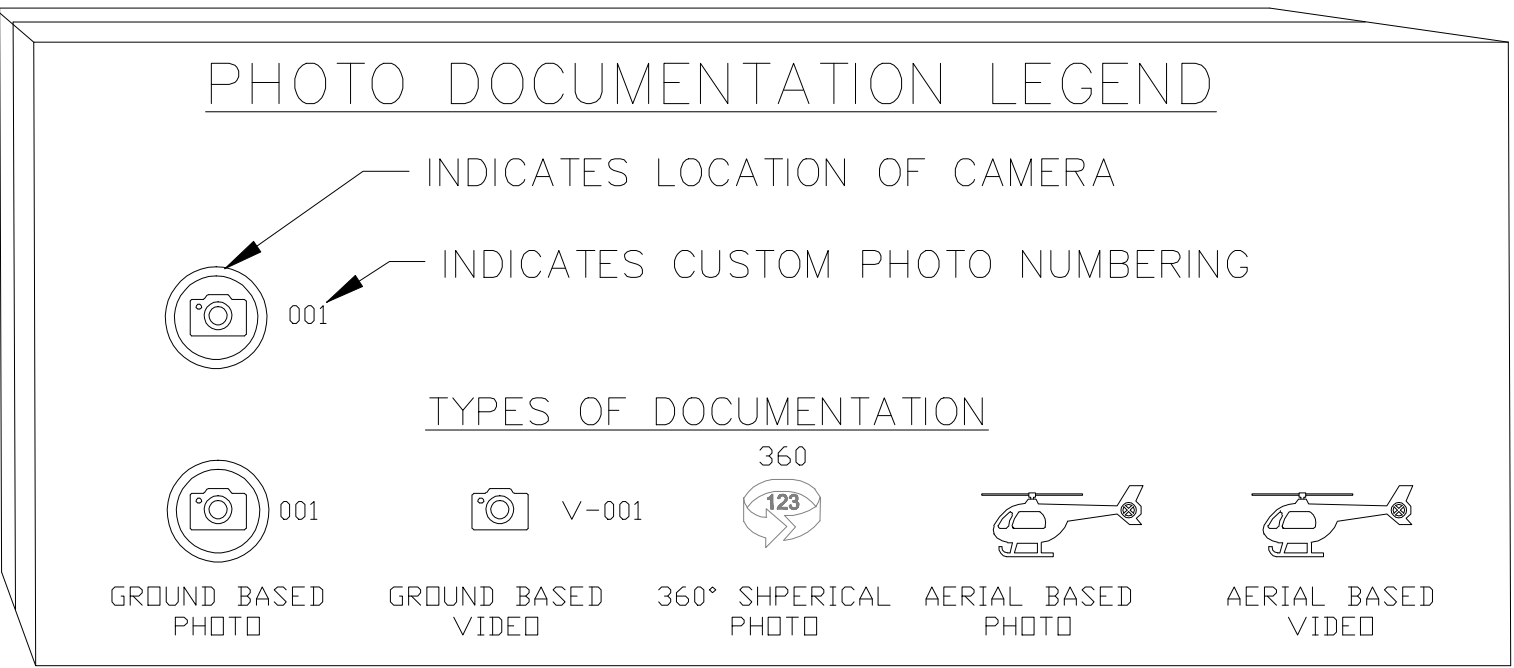



As BUILT
PROFESSIONALS
www.asbuiltprofessionals.com
A DIVISION OF:




AEC
CONSULTANTS INC
844.272.8458
844 A S BUILT
© 2021 AEC CONSULTANTS INC

ARCHITECTURAL AS BUILT
Walnut Hill Apartments
Cordova, TN 38018

</		

SL

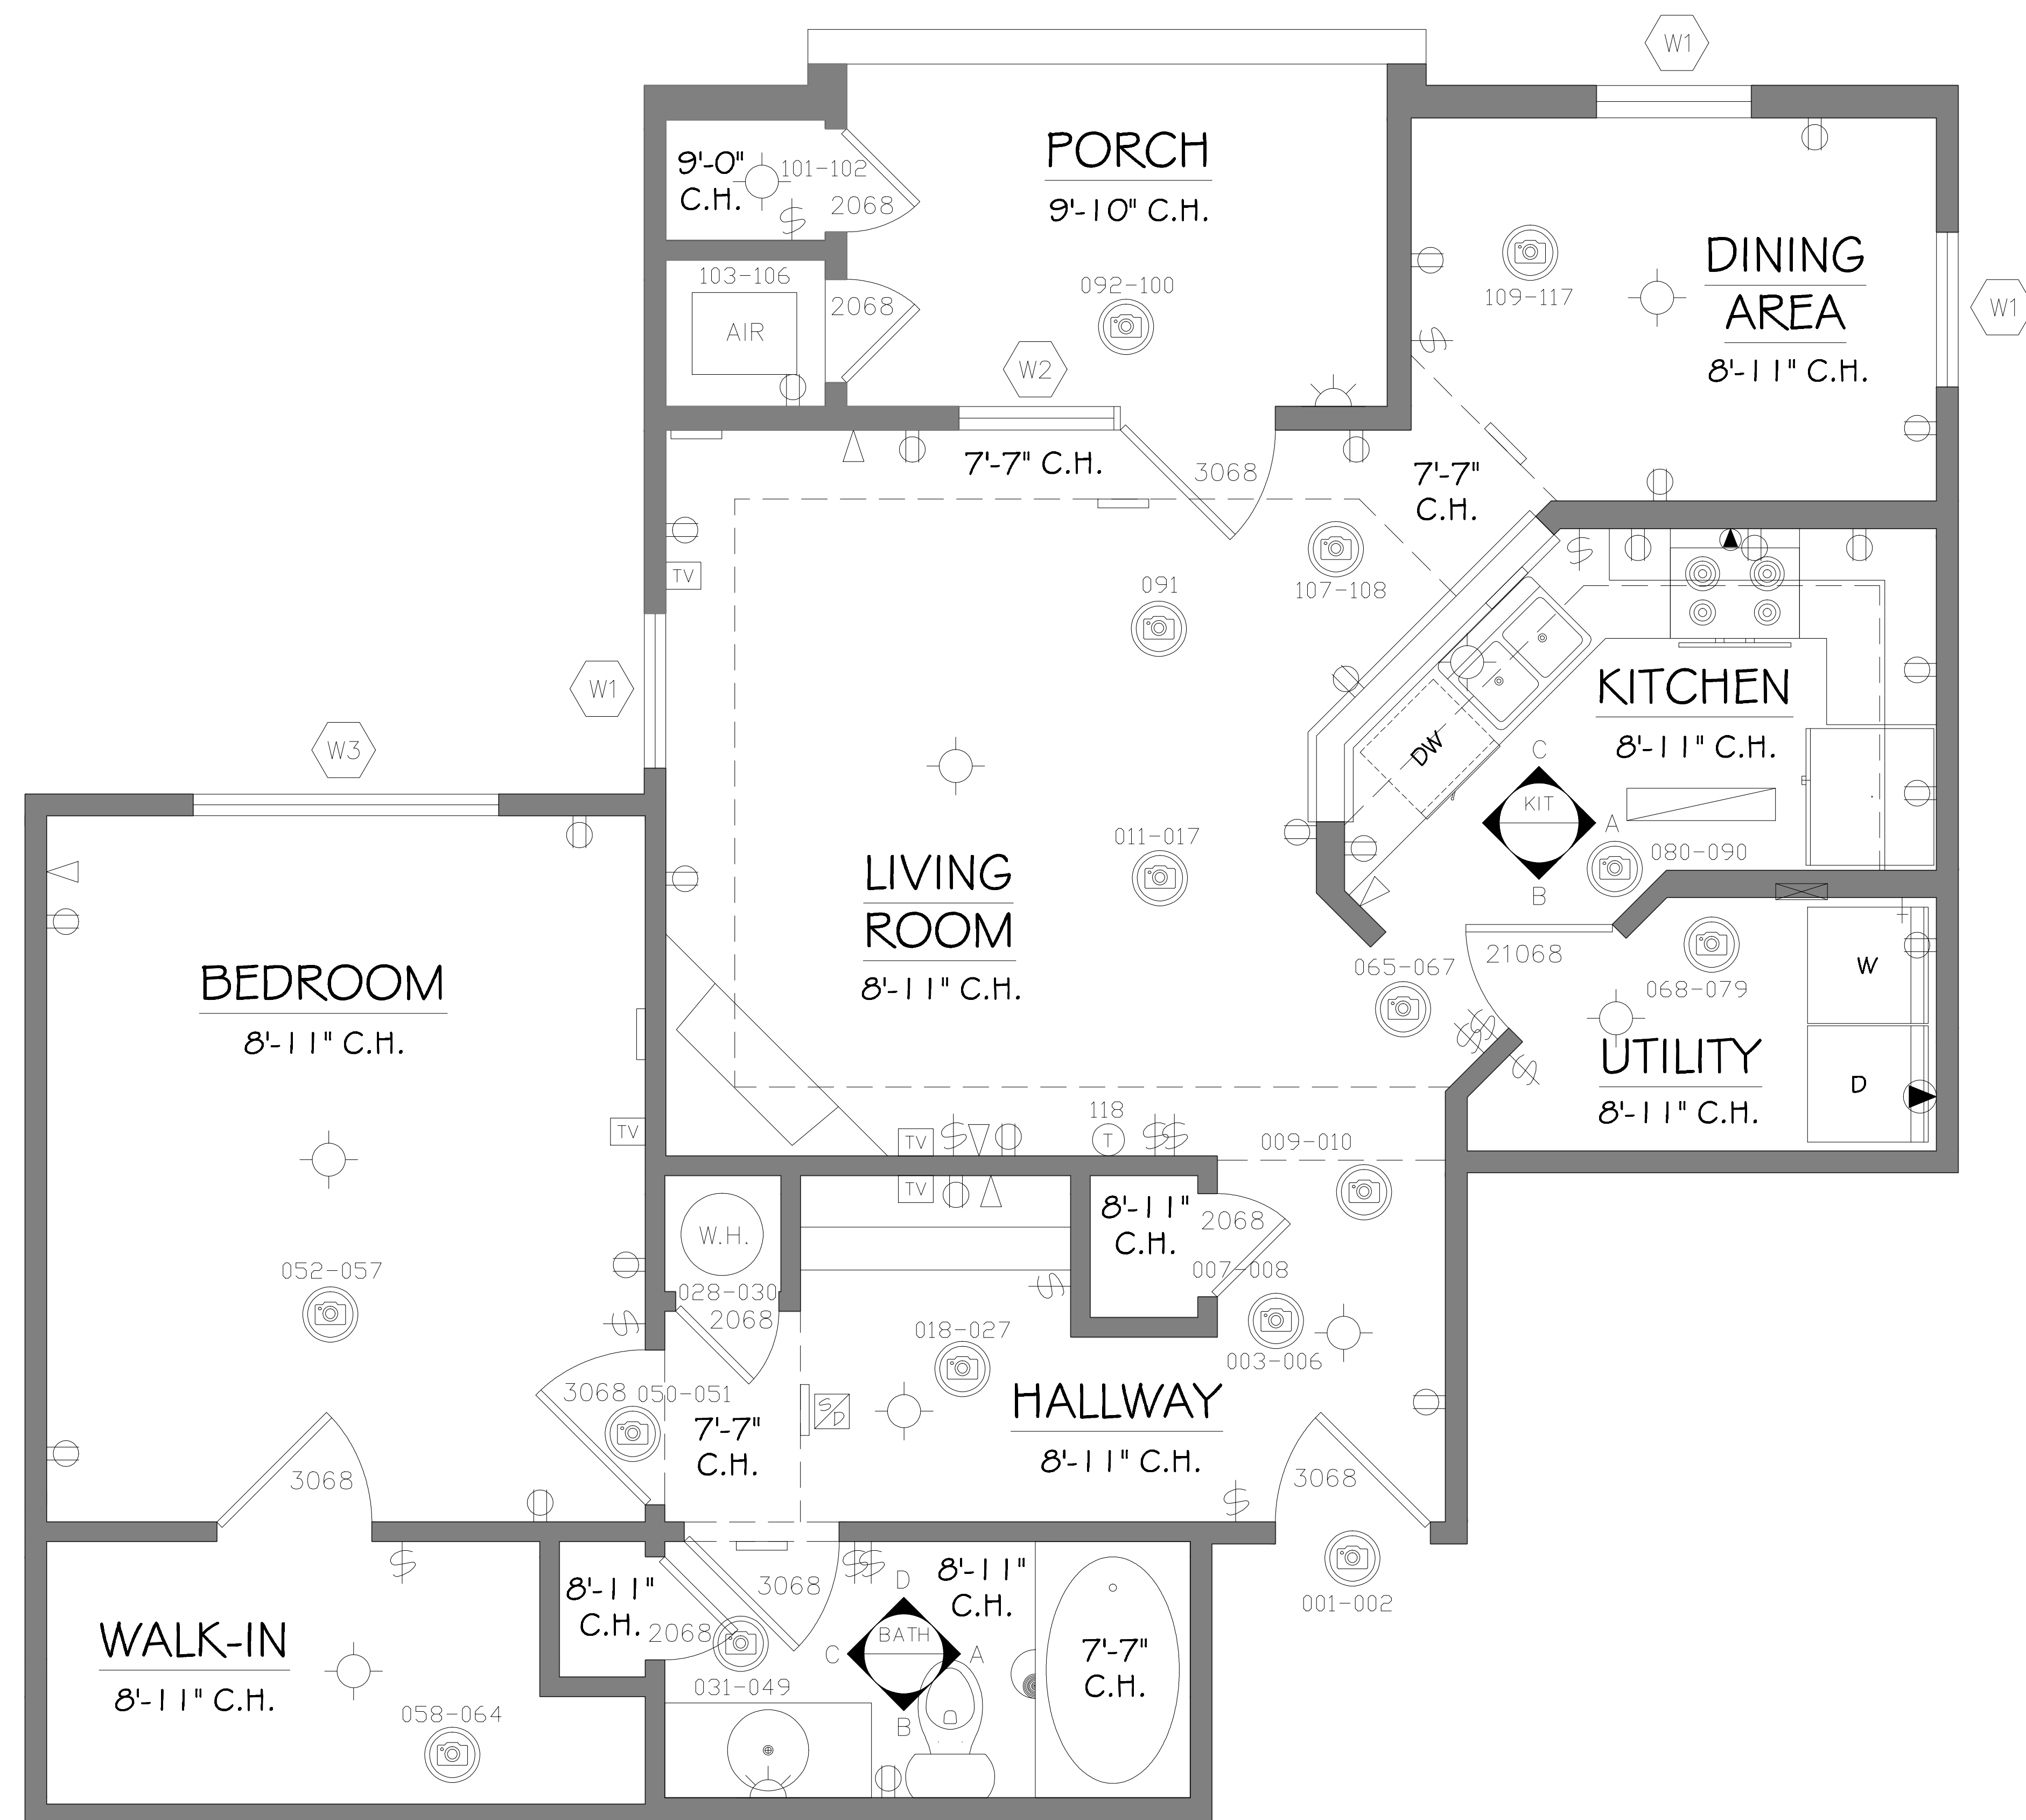


MEP ITEM COUNT	
ITEM	Total Count
Outlets	27
Phone Jacks	5
Data Ports	0
Cable Jacks	3
Switches	15
Dryer Outlet	1
Range Outlet	1

01		
NO.	ISSUES REVISIONS	DATE
		SHEET TITLE
UNIT - 8940G101		
HL		PROJECT MANAGER
HL		PROJECT DIRECTOR
012317-1		PROJECT NUMBER
1/2"=1'-0"		SCALE
BB		DRAWN BY
		SHEET NUMBER
AB-1		

MEP ITEM COUNT

ITEM	Total Count
Outlets	26
Phone Jacks	6
Data Ports	0
Cable Jacks	5
Switches	16
Dryer Outlet	1
Range Outlet	1

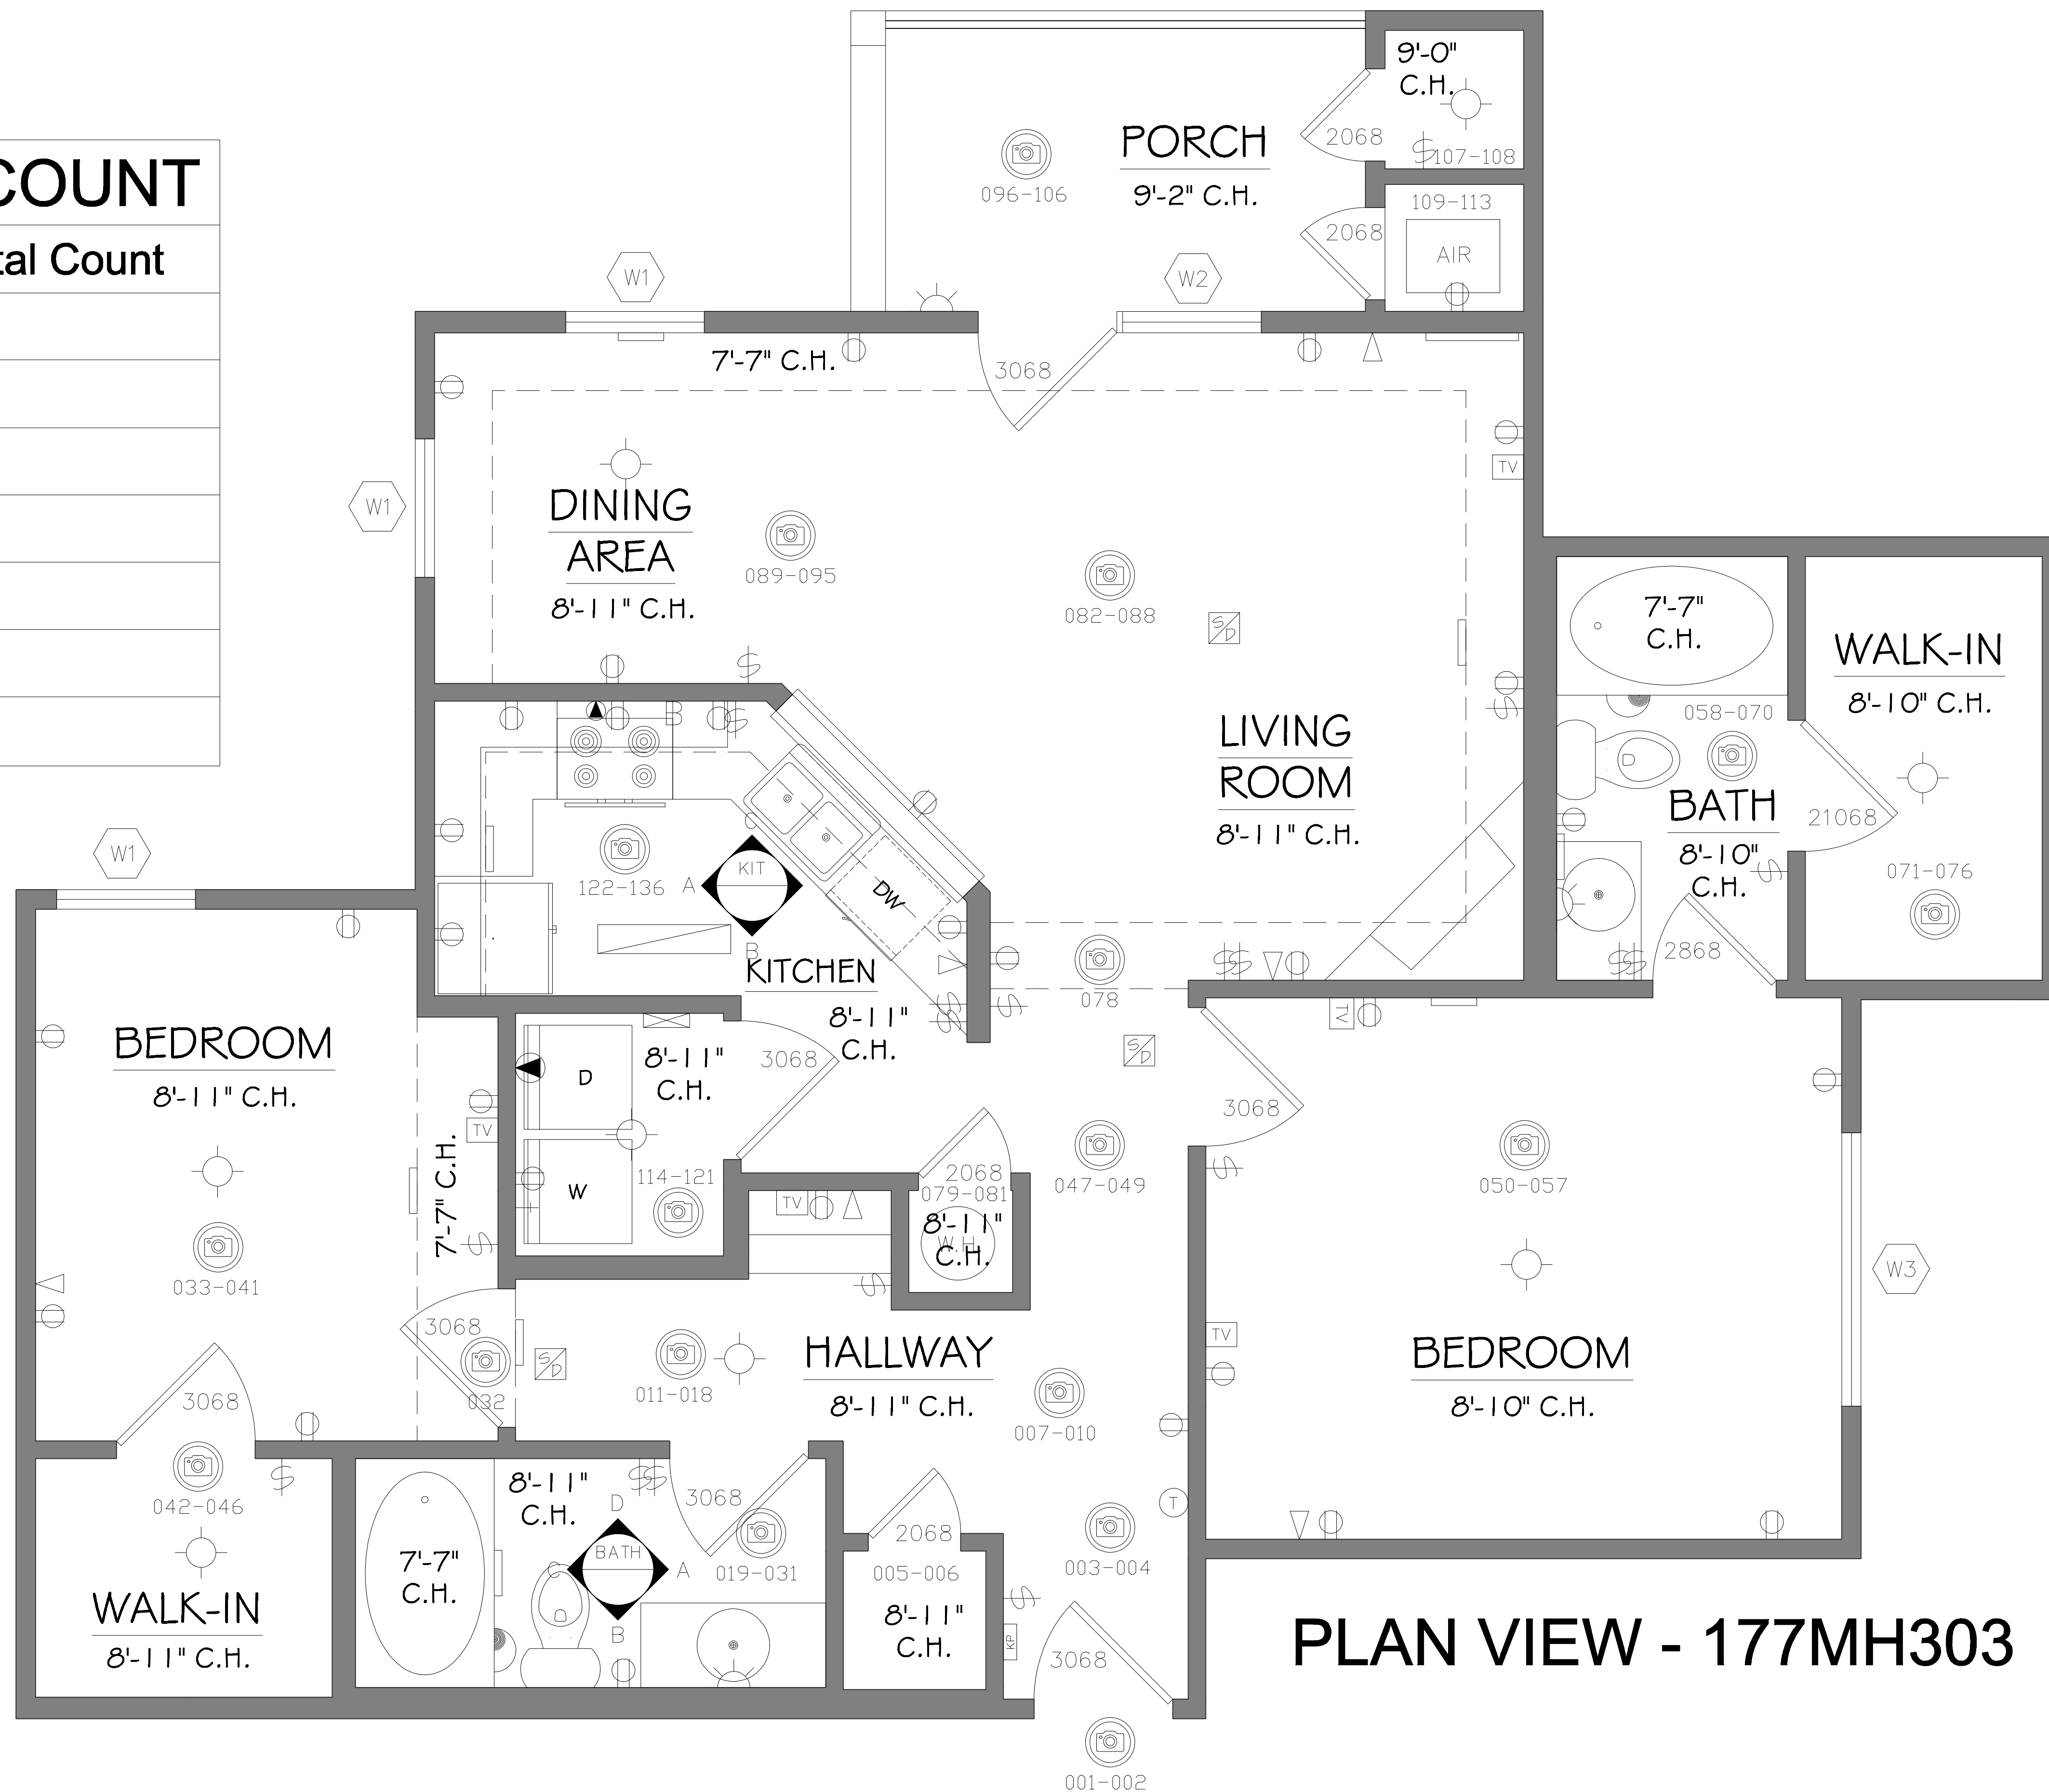

PLAN VIEW - 177MH303

As BUILT
PROFESSIONALS
www.asbuiltprofessionals.com
A DIVISION OF:

AEC
CONSULTANTS INC
844.272.8458
844 ASBUILT


© 2021 AEC CONSULTANTS INC

ARCHITECTURAL AS BUILT

Walnut Hill Apartments

Cordova, TN 38018

01		
NO.	ISSUES REVISIONS	DATE
		SHEET TITLE
UNIT - 177MH303		
HL	PROJECT MANAGER	
HL	PROJECT DIRECTOR	
012317-1	PROJECT NUMBER	
1/2"=1'-0"	SCALE	
BB	DRAWN BY	
		SHEET NUMBER
AB-2		

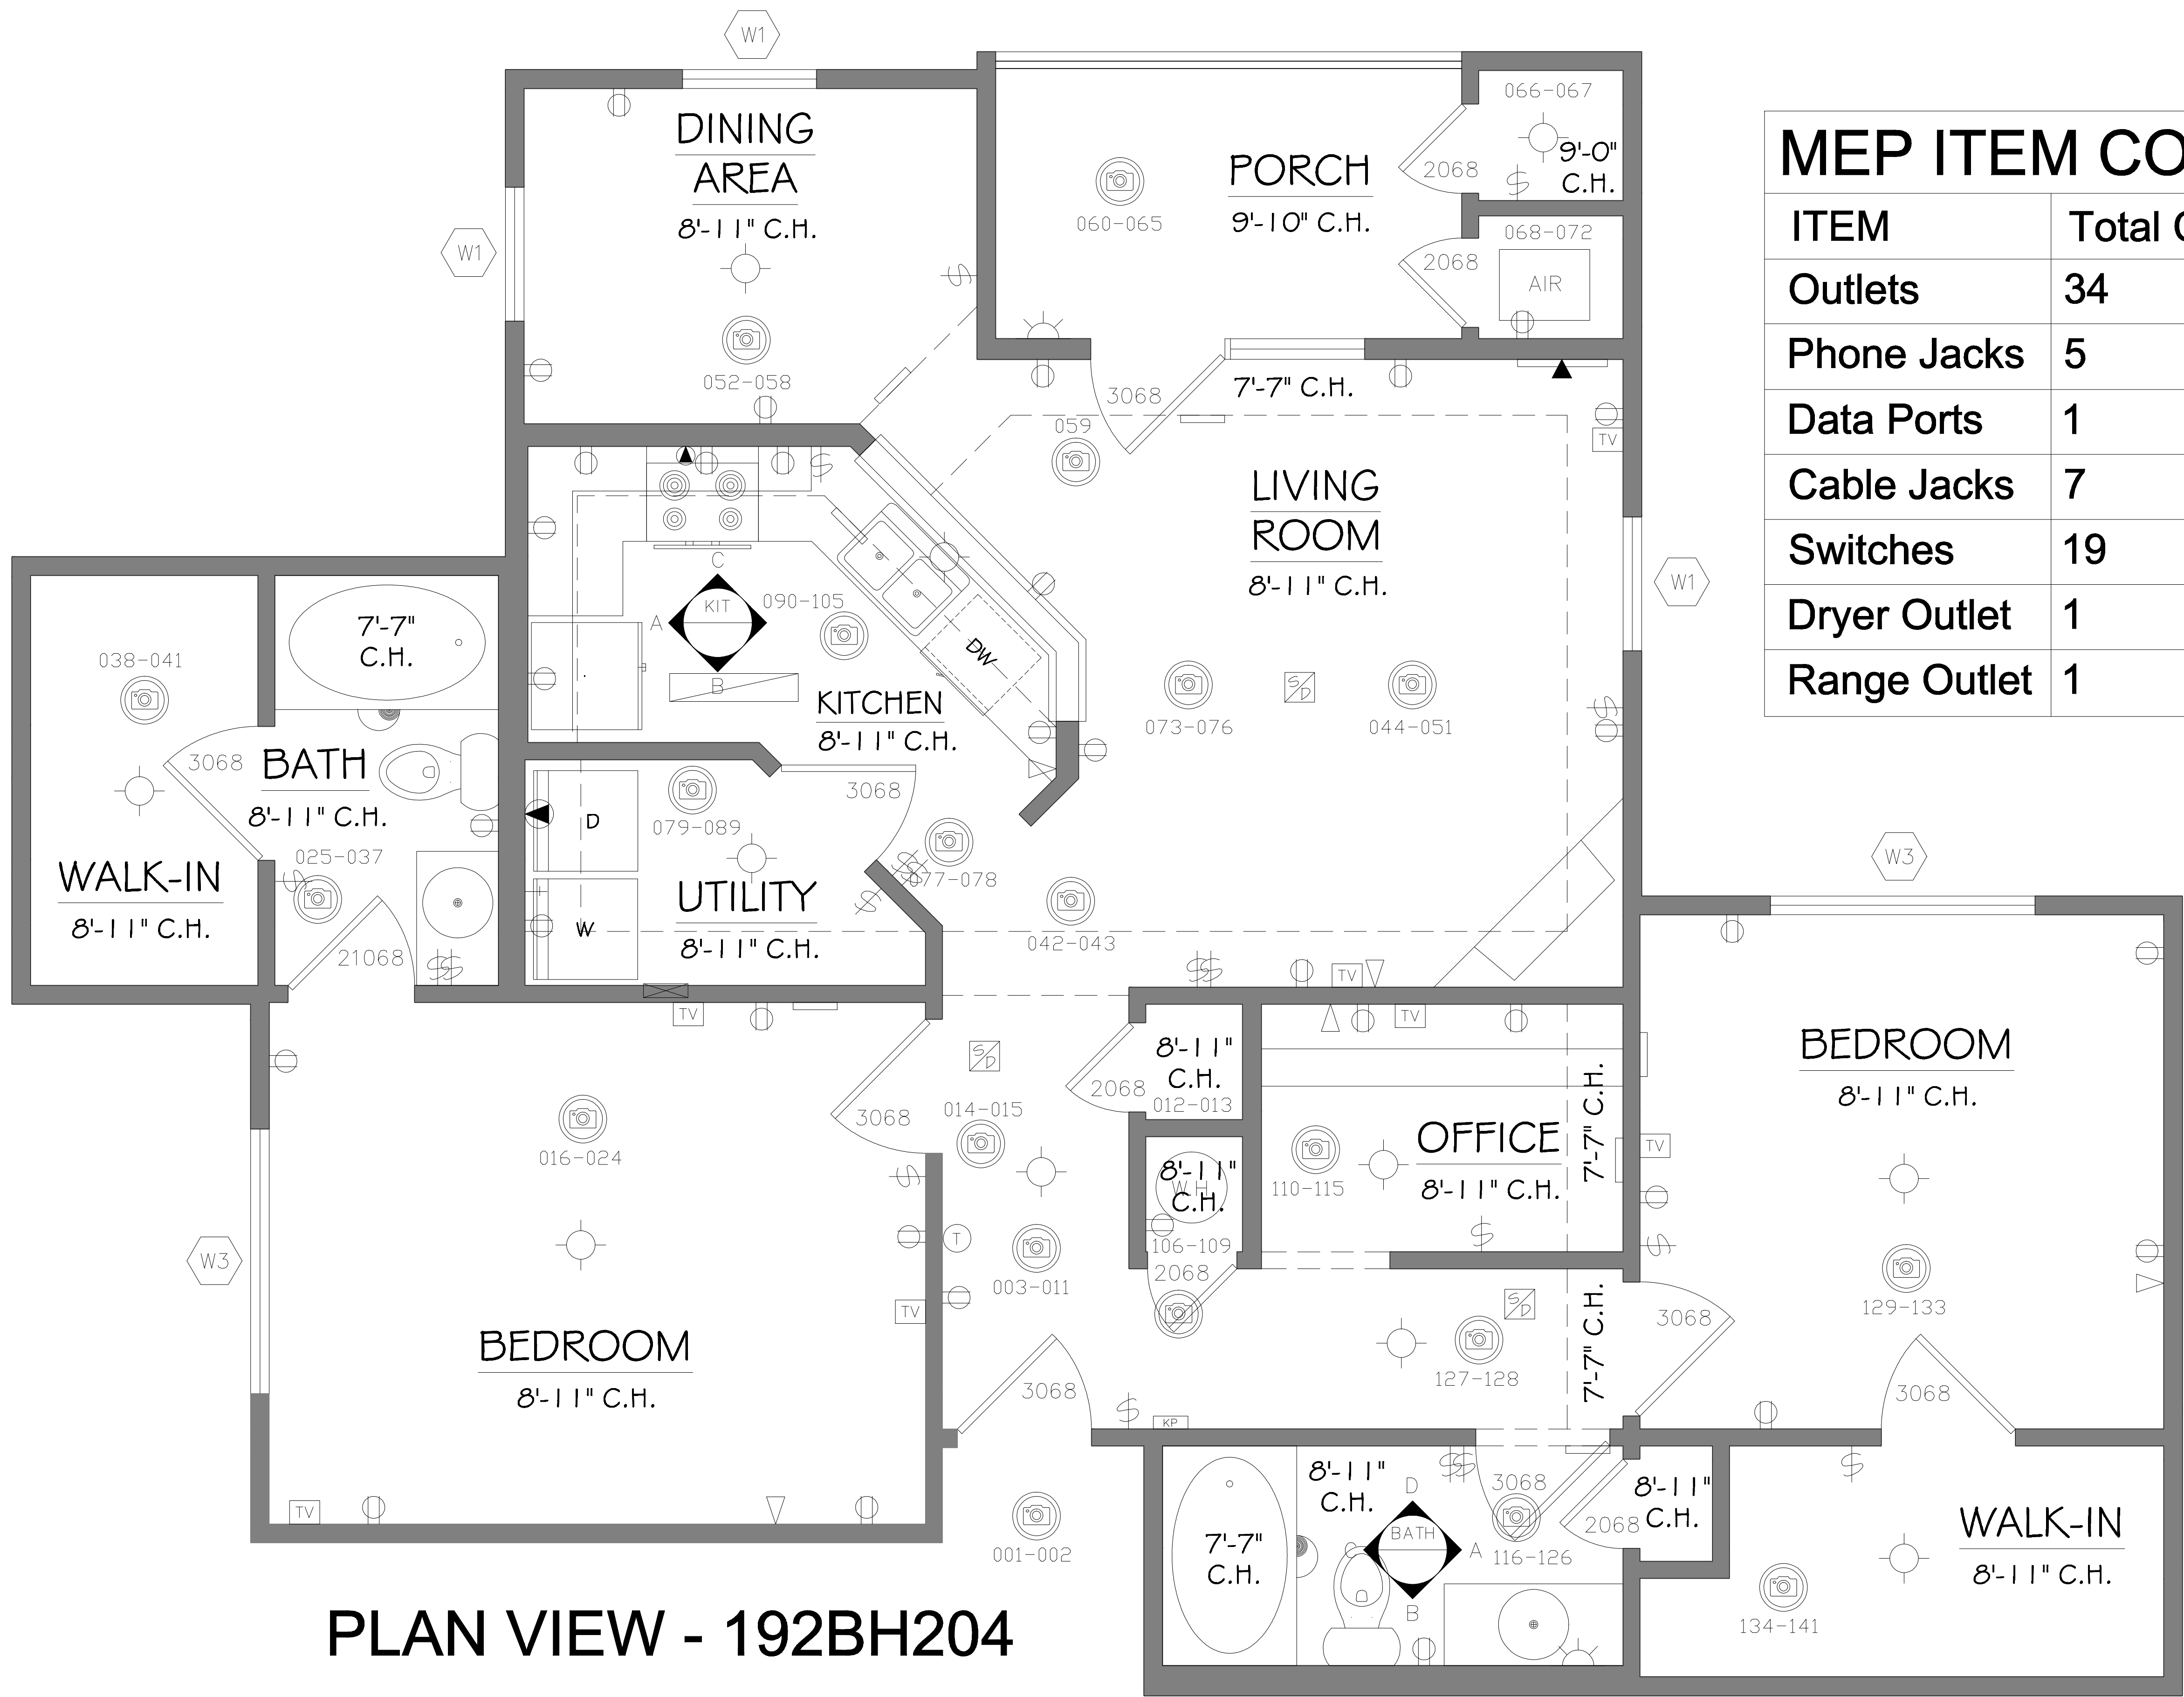

PLAN VIEW - 192BH204

MEP ITEM COUNT

ITEM	Total Count
Outlets	34
Phone Jacks	5
Data Ports	1
Cable Jacks	7
Switches	19
Dryer Outlet	1
Range Outlet	1

ARCHITECTURAL AS BUILT
Walnut Hill Apartments

Cordova, TN 38018

01	ISSUES REVISIONS	DATE
NO.		


UNIT - 192BH204

HL	PROJECT MANAGER
HL	PROJECT DIRECTOR
012317-1	PROJECT NUMBER
1/2"=1'-0"	SCALE
BB	DRAWN BY
	SHEET NUMBER

AB-3

MEP ITEM COUNT

ITEM	Total Count
Outlets	39
Phone Jacks	8
Data Ports	0
Cable Jacks	6
Switches	25
Dryer Outlet	1
Range Outlet	1

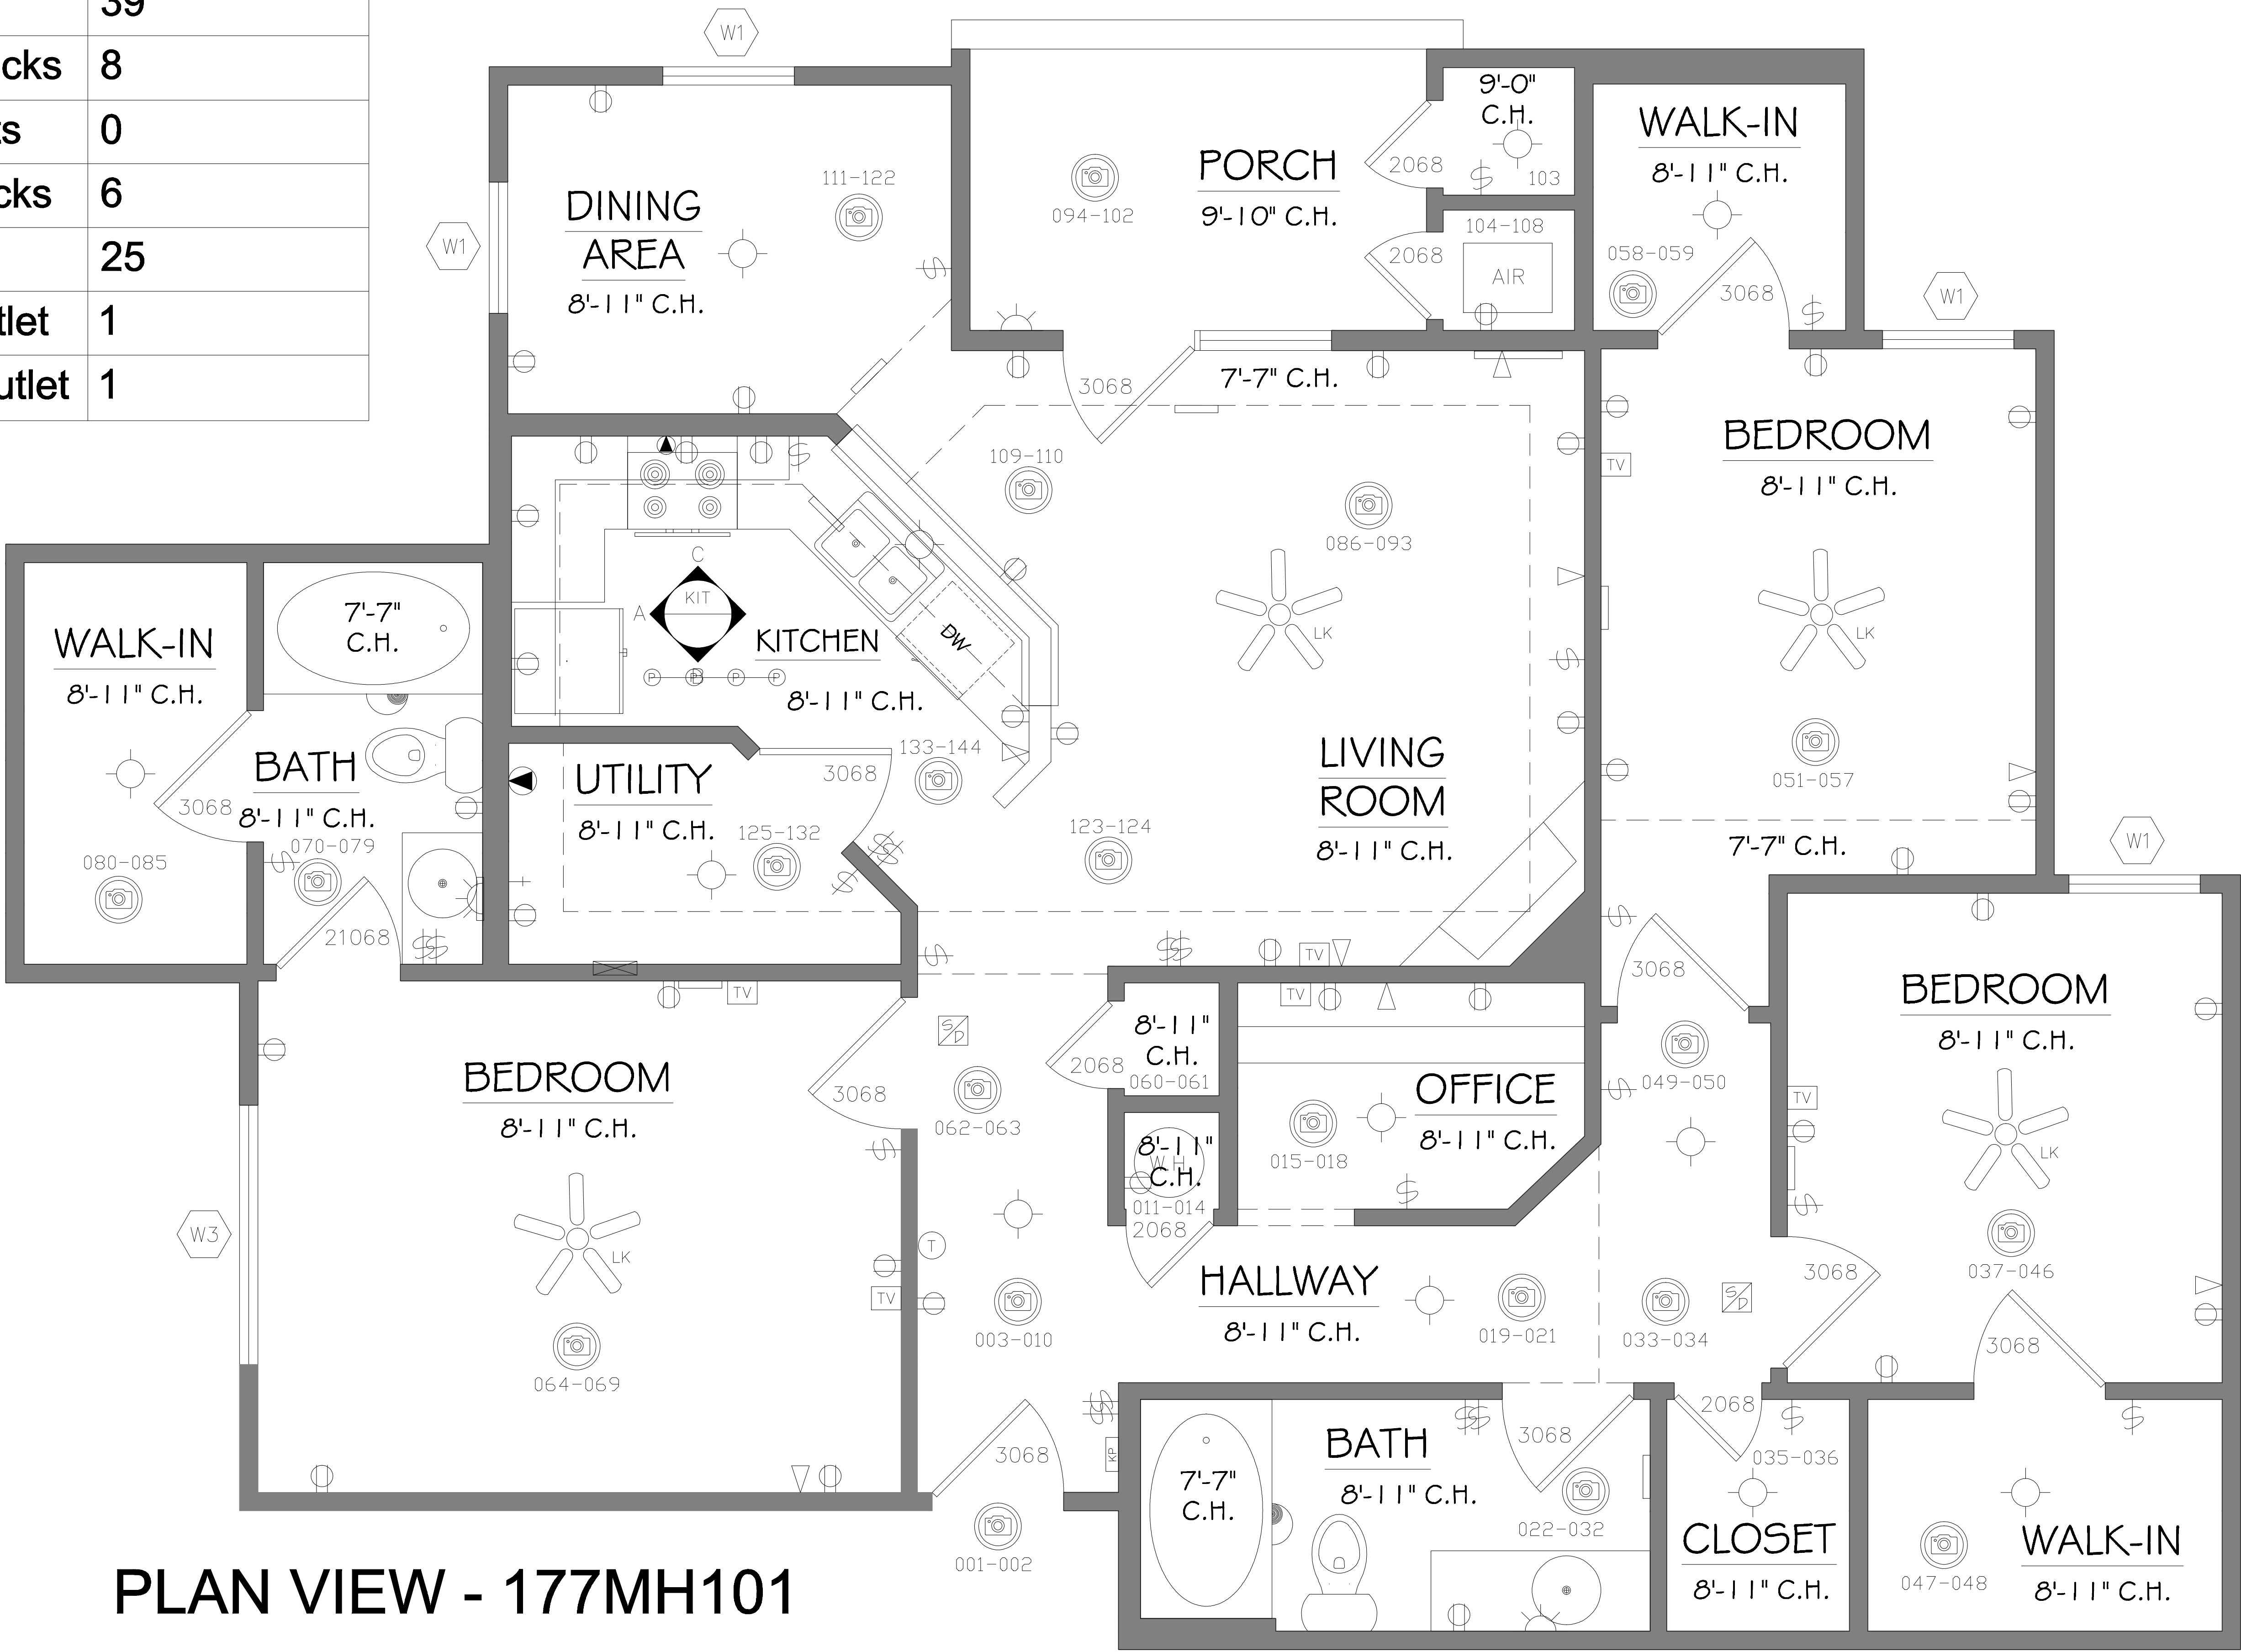

PLAN VIEW - 177MH101

As BUILT
PROFESSIONALS
www.asbuiltprofessionals.com
A DIVISION OF:

AEC

CONSULTANTS INC

844.272.8458
844 ASBUILT

© 2021 AEC CONSULTANTS INC


ARCHITECTURAL AS BUILT

Walnut Hill Apartments


Cordova, TN 38018

01		
NO.	ISSUES REVISIONS	DATE
		SHEET TITLE
UNIT - 177MH101		
HL	PROJECT MANAGER	
HL	PROJECT DIRECTOR	
012317-1	PROJECT NUMBER	
1/2"=1'-0"	SCALE	
BB	DRAWN BY	
		SHEET NUMBER
AB-4		


192BH204 KITCHEN ELEVATIONS

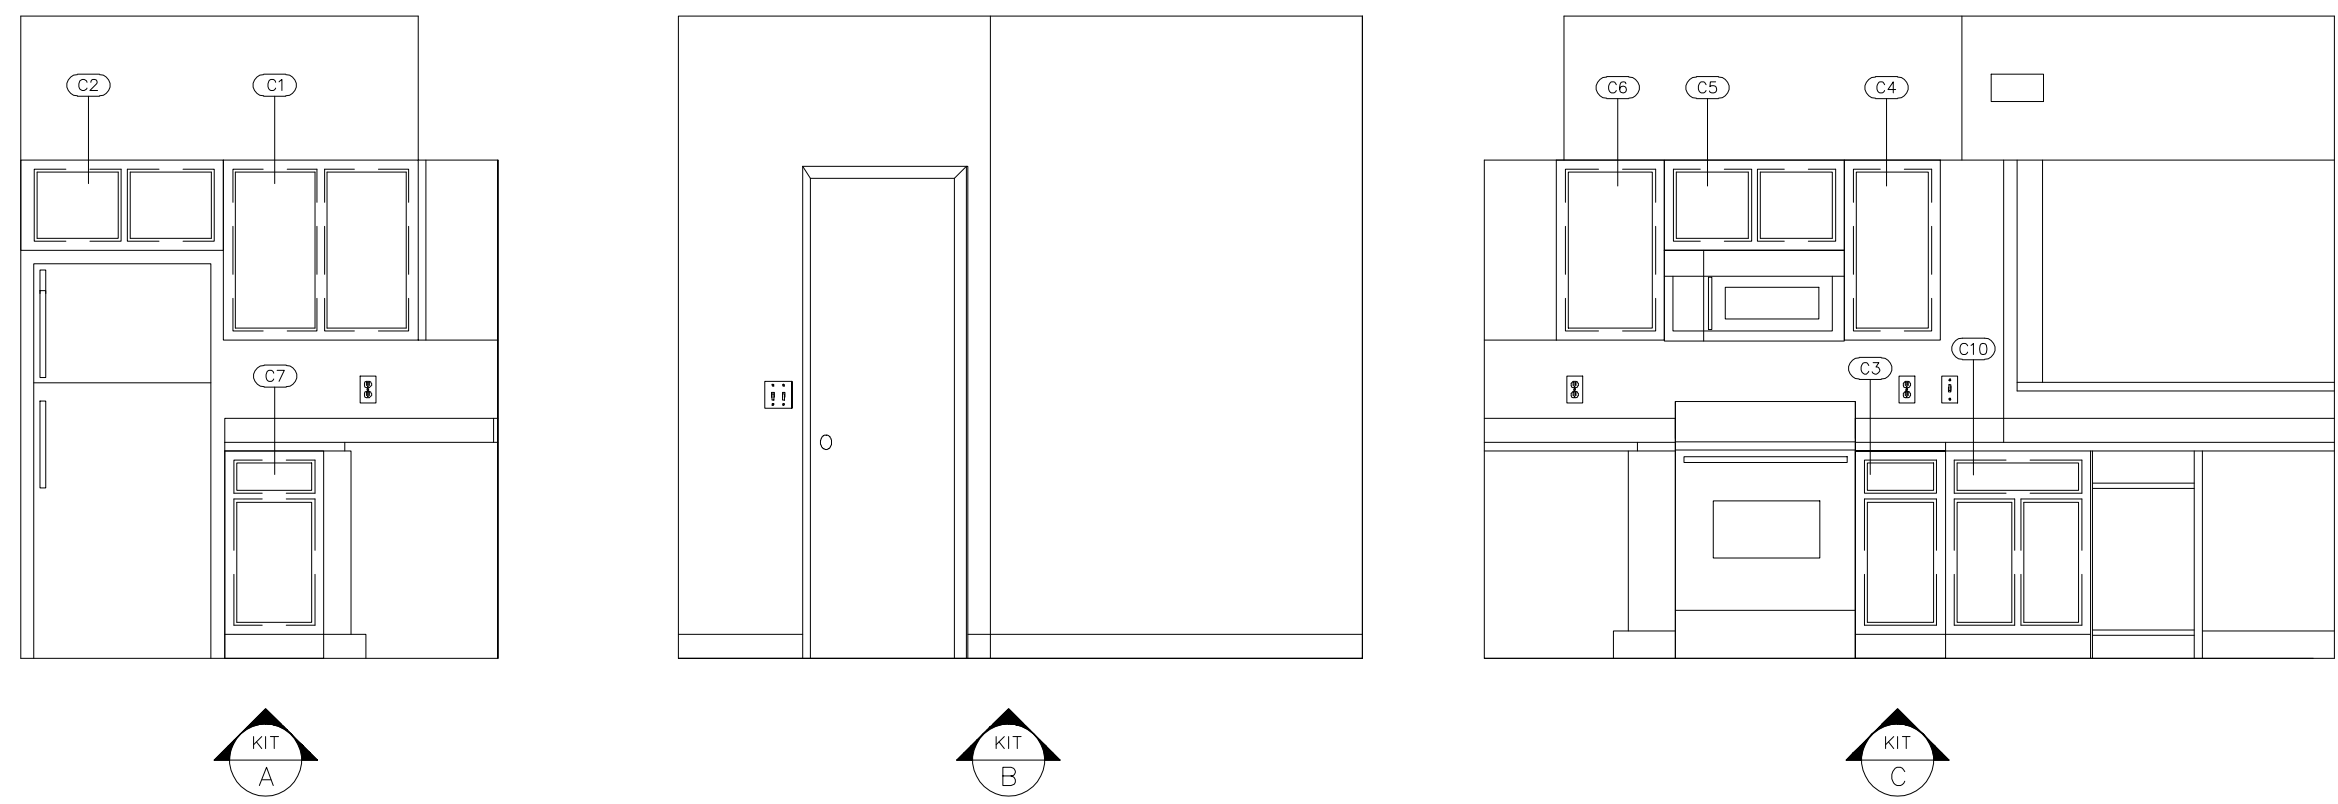


192BH204 BATHROOM ELEVATIONS

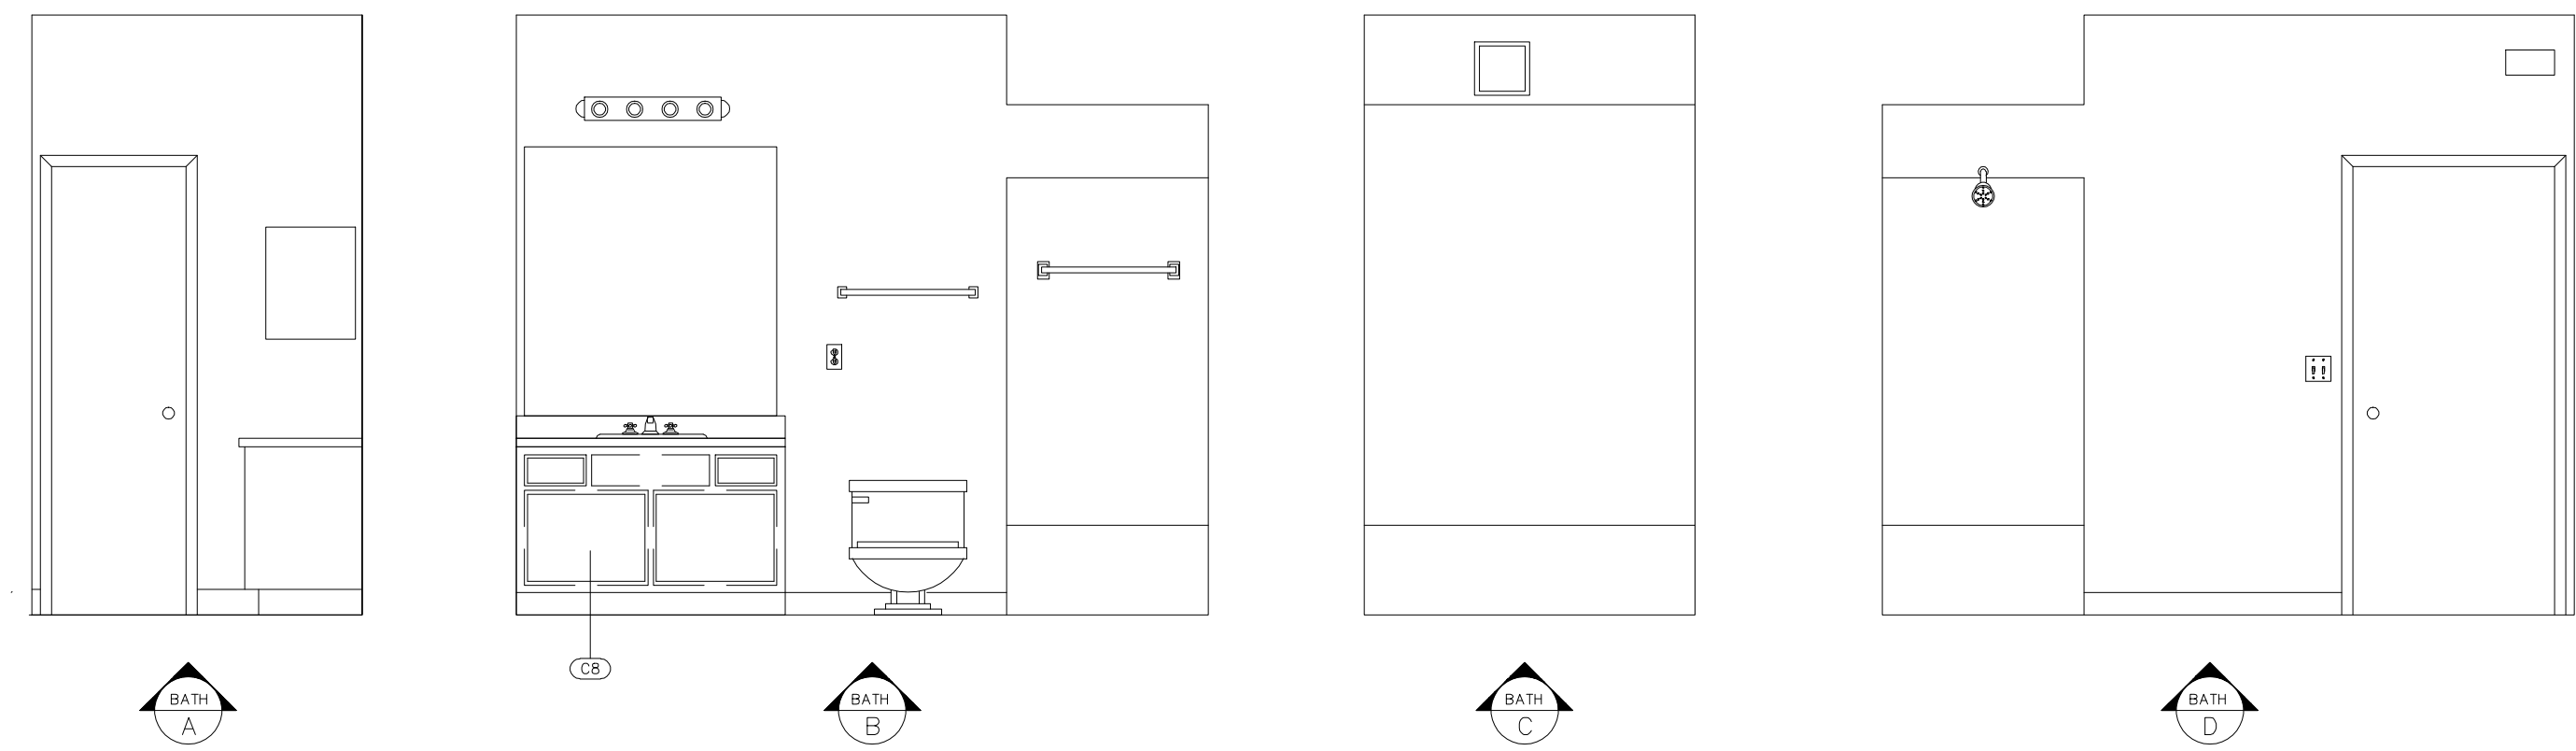


177MH101 KITCHEN ELEVATIONS

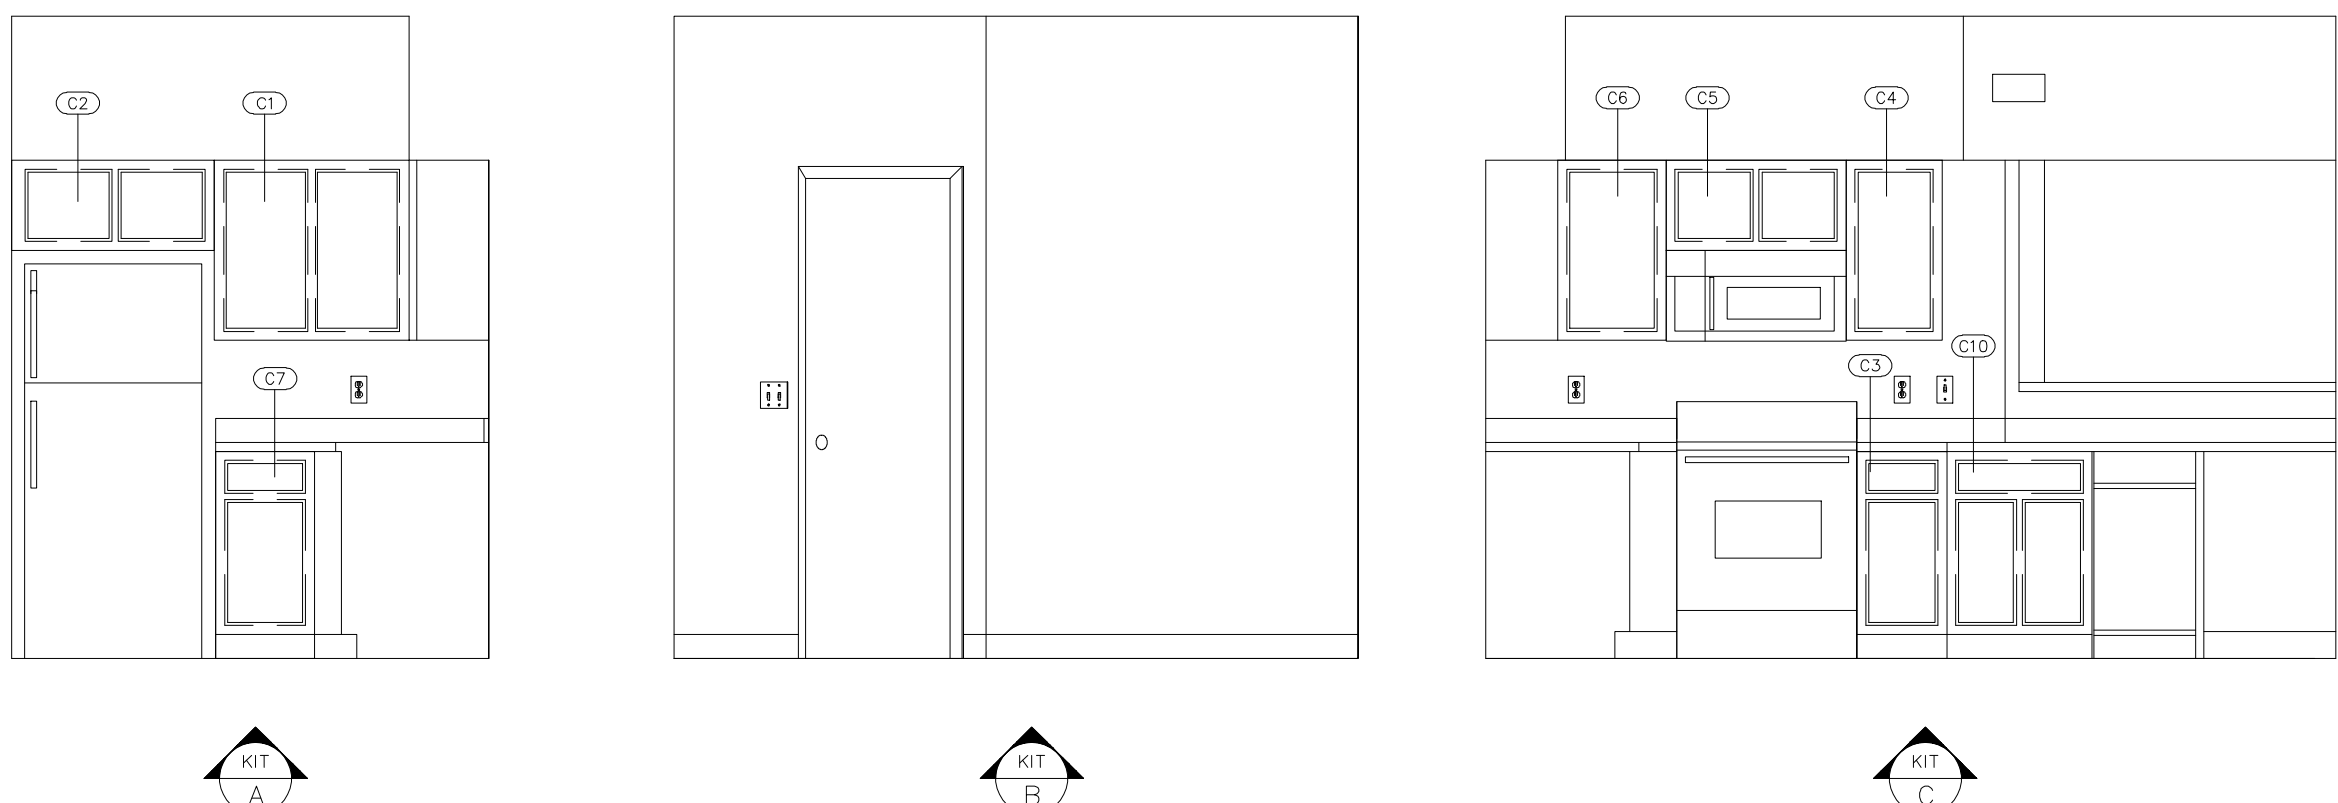


177MH101 BATHROOM ELEVATIONS

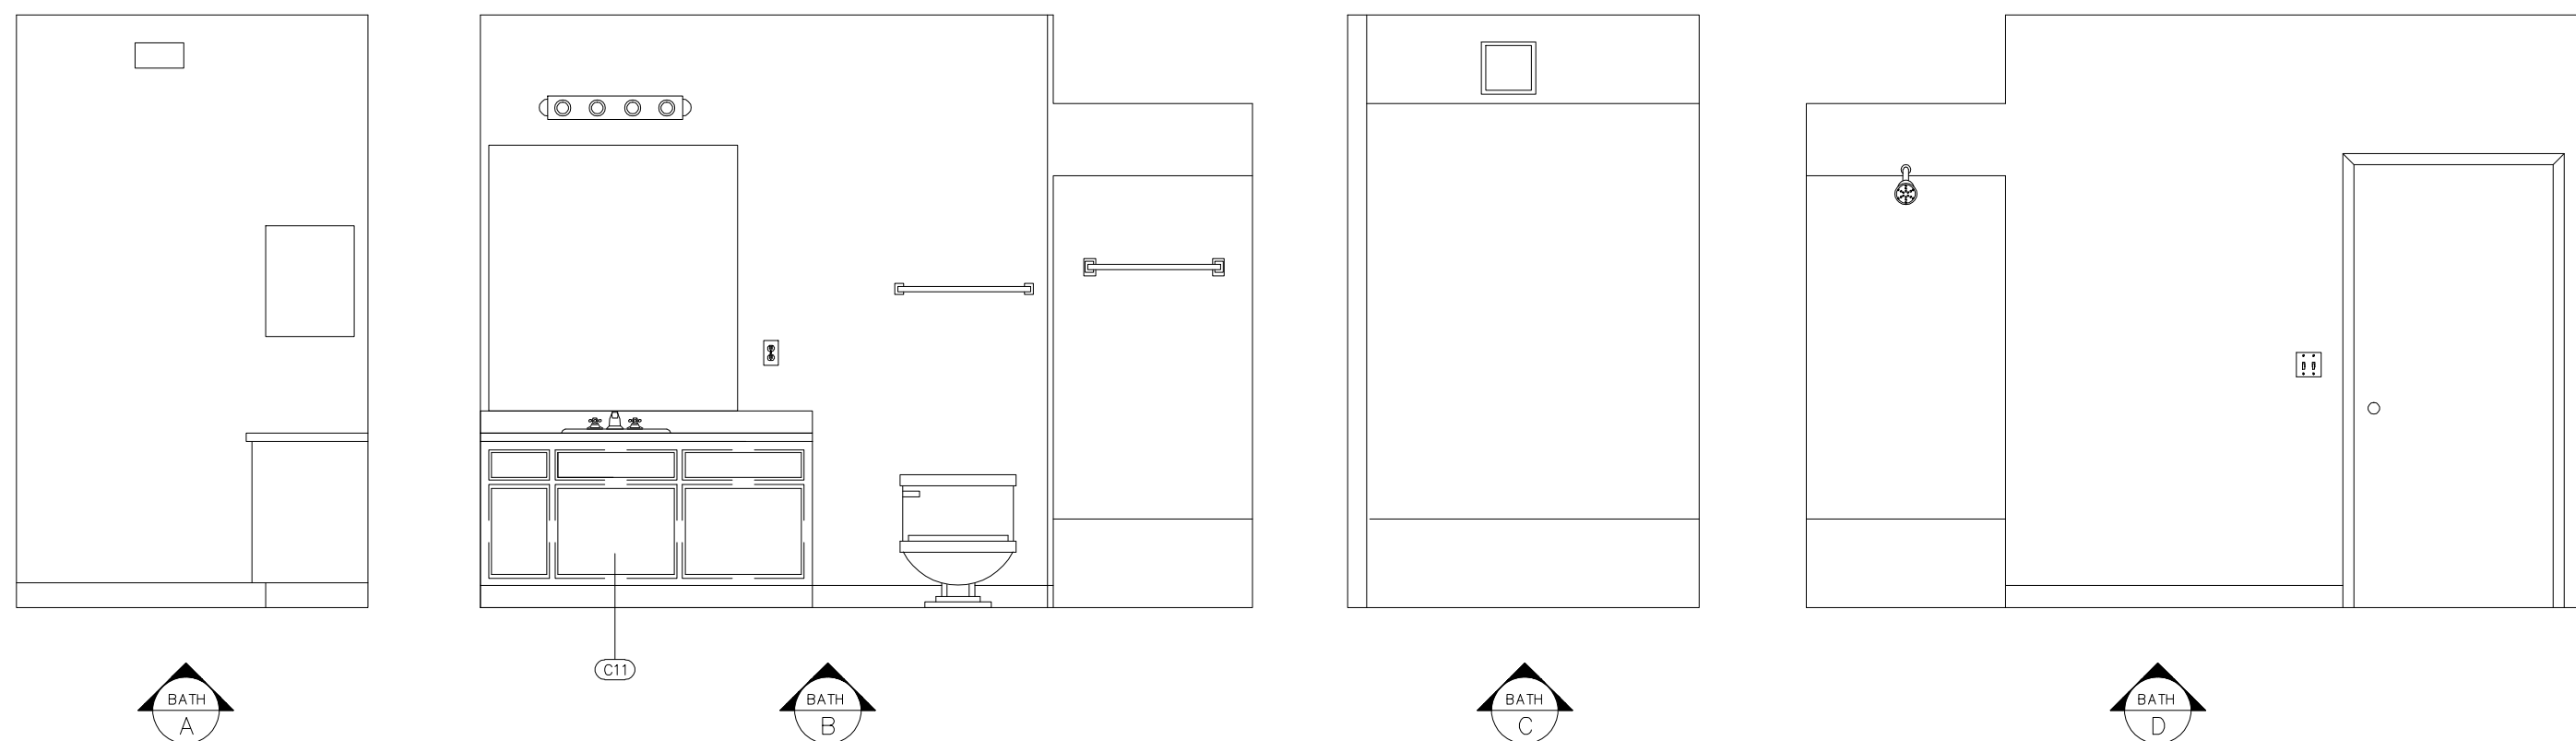


177MH303 KITCHEN ELEVATIONS

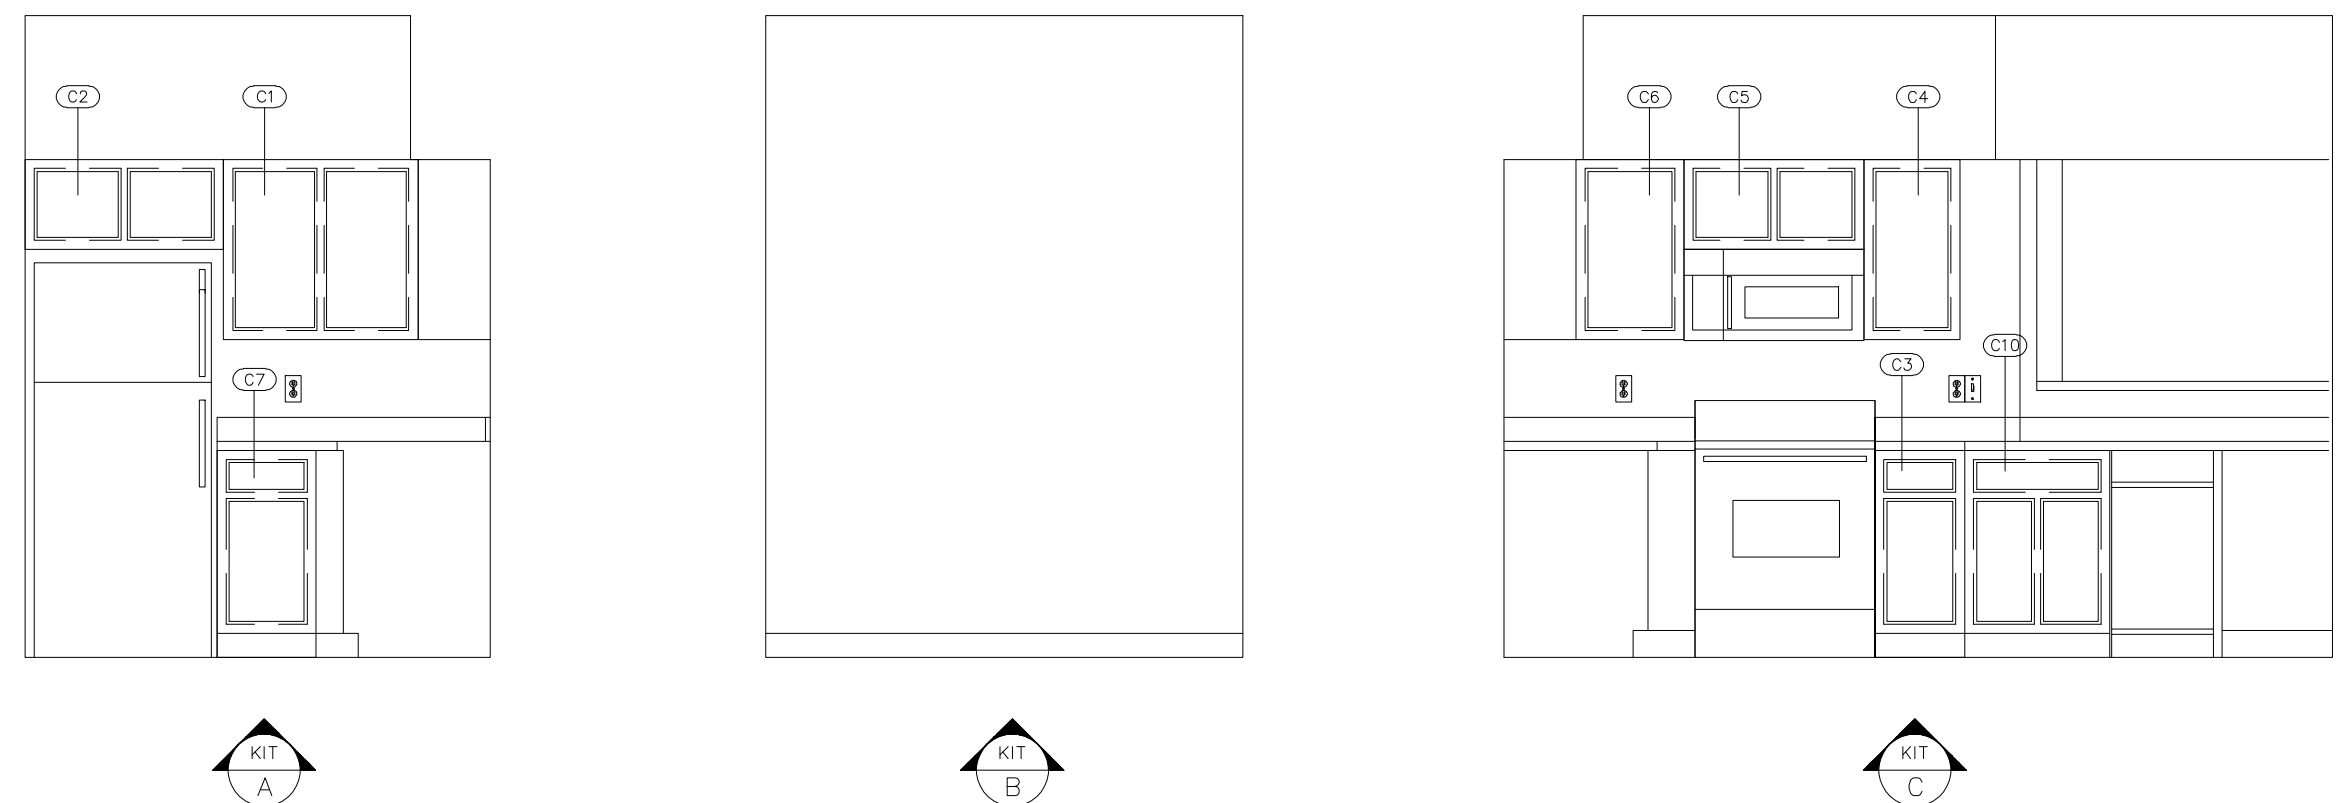


177MH303 BATHROOM ELEVATIONS

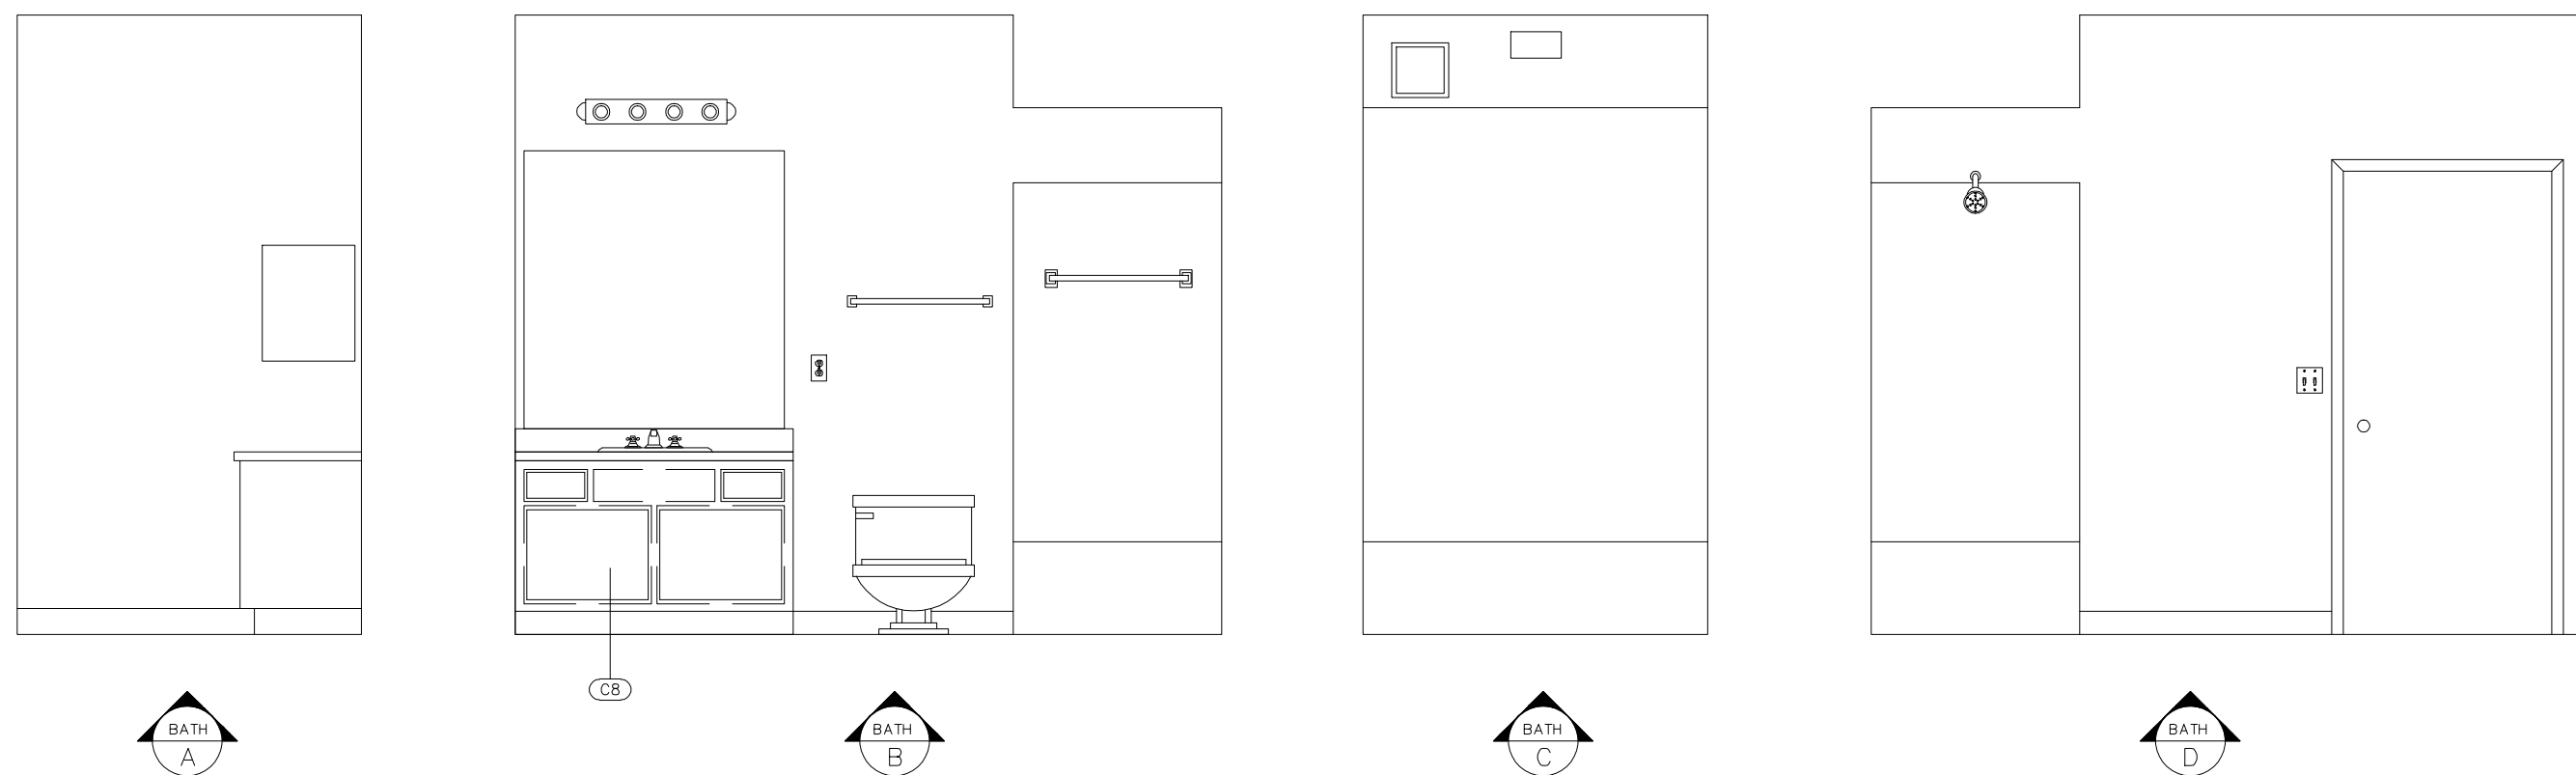

8940G101 KITCHEN ELEVATIONS

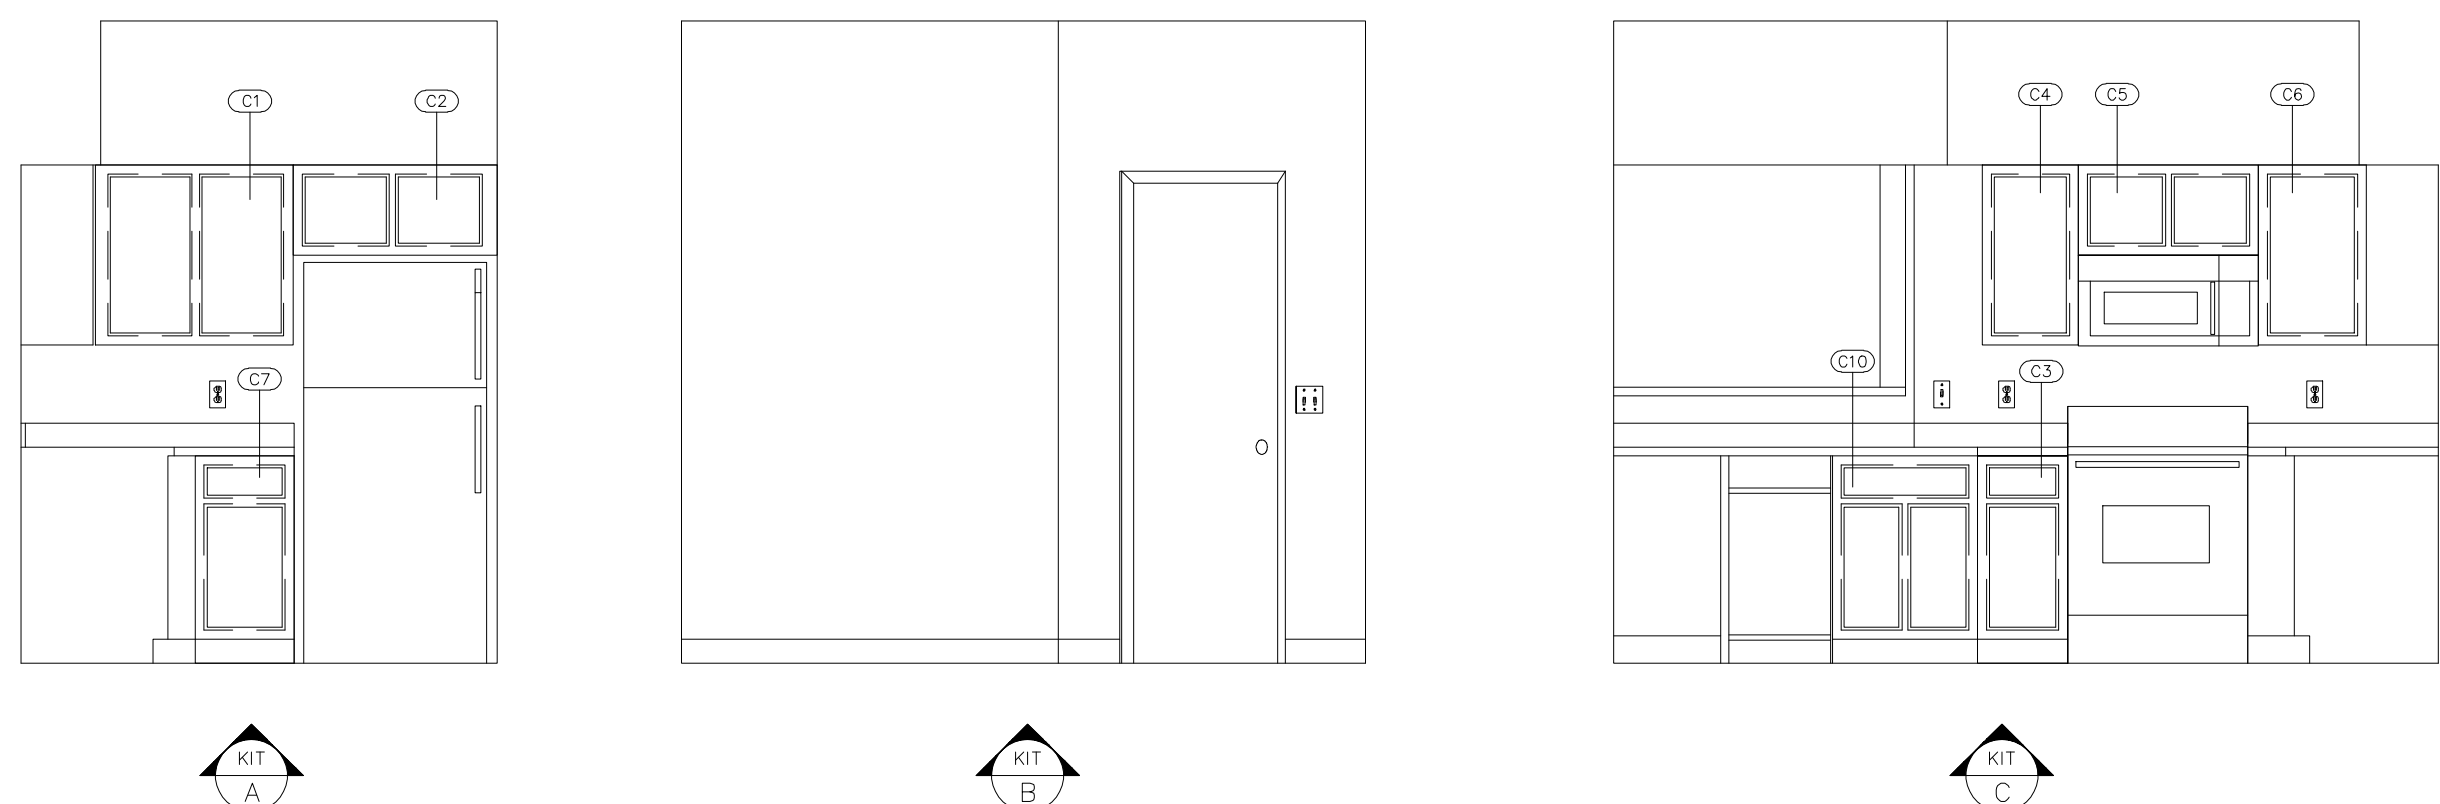

8940G101 BATHROOM ELEVATIONS

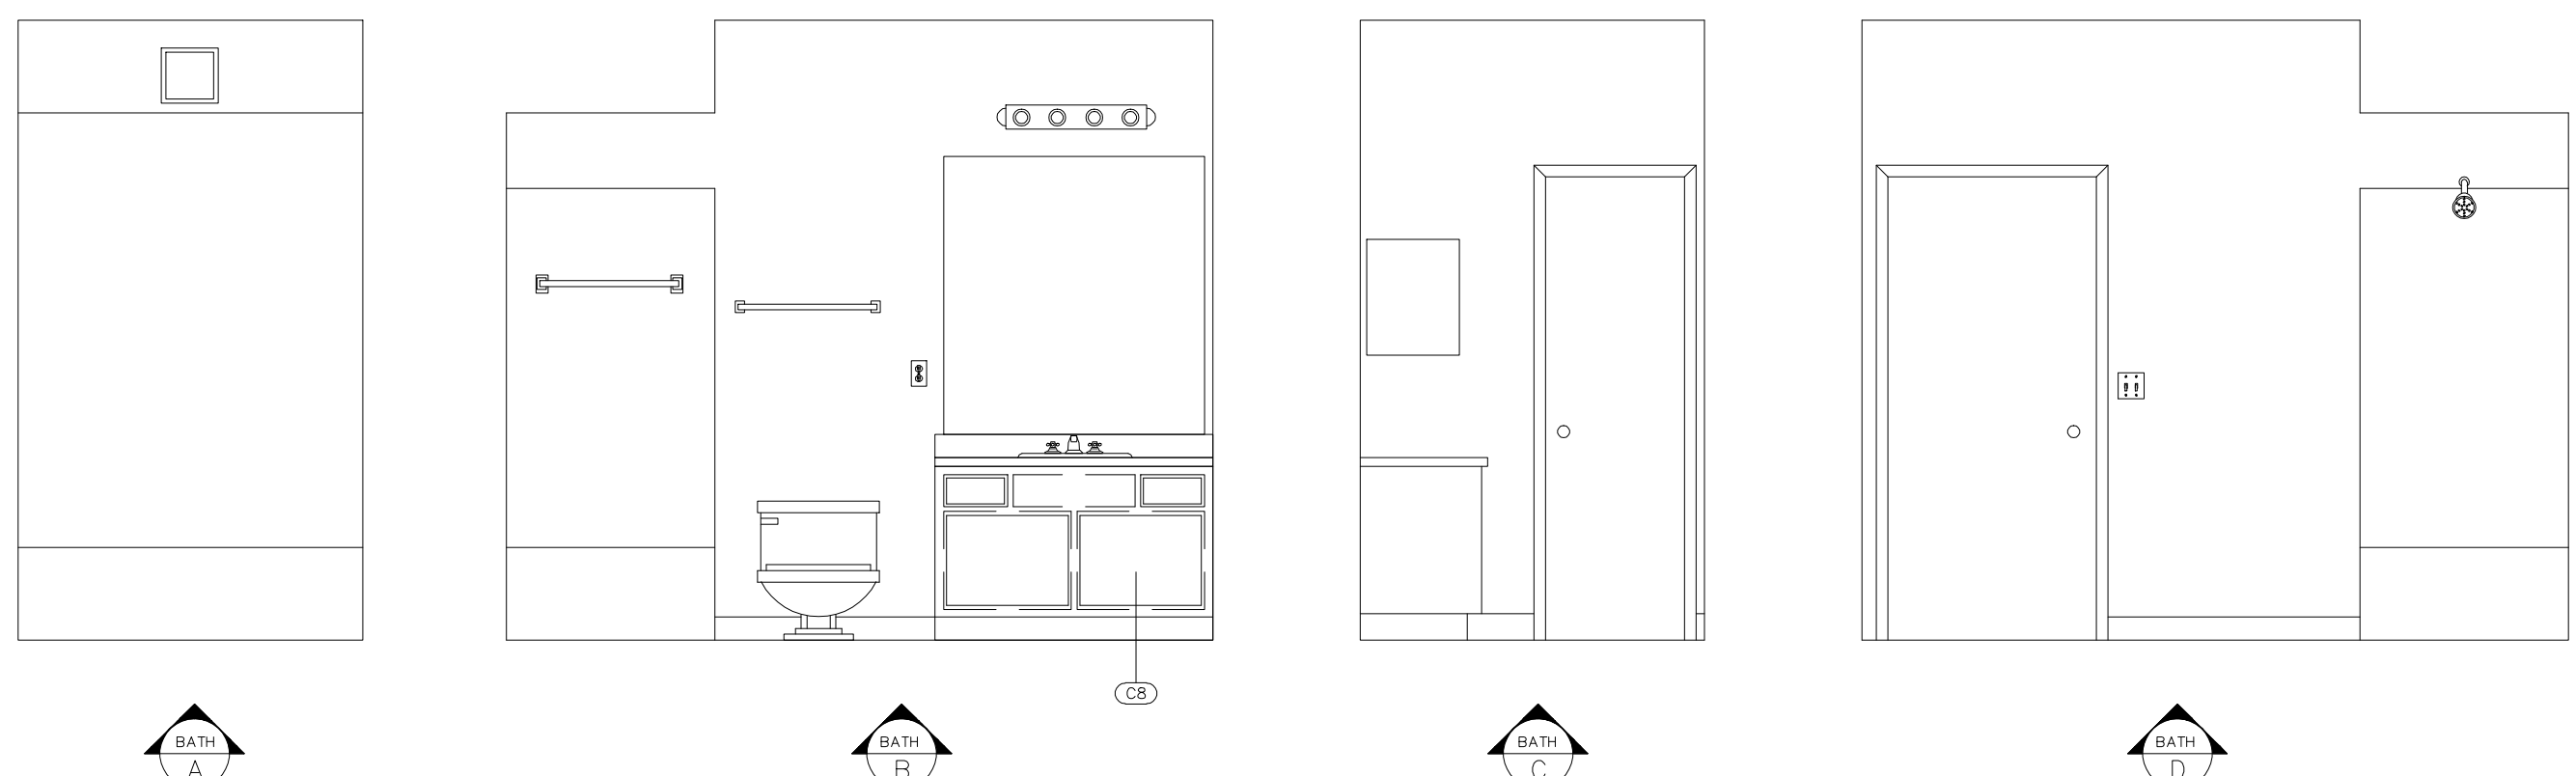


As BUILT PROFESSIONALS
www.asbuiltprofessionals.com
A DIVISION OF:
AEC CONSULTANTS INC
844.272.8458
844 A S BUILT
© 2021 AEC CONSULTANTS INC

ARCHITECTURAL AS BUILT
Walnut Hill Apartments
Cordova, TN 38018

01		
NO.	ISSUES REVISIONS	DATE
SHEET TITLE		
INTERIOR ELEVATIONS		
HL	PROJECT MANAGER	
HL	PROJECT DIRECTOR	
012317-1	PROJECT NUMBER	
3/8"=1'-0"	SCALE	
BB	DRAWN BY	
SHEET NUMBER		
AB-5		





FEATURES LIST

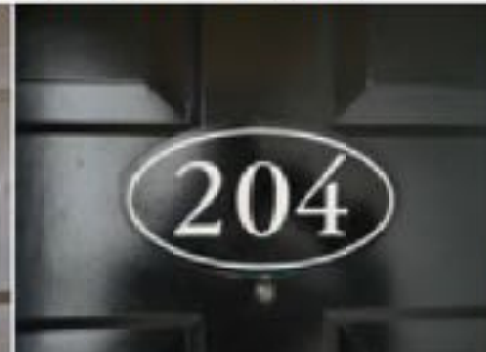FEATURE	ATTRIBUTE	8940G101	177MH303	192BH204	177MH101	CLUBHOUSE
Ceiling Fan	Diameter	NONE	NONE	NONE	48"	NONE
Ceiling Light	Size	4'-0" X 10"	4'-0" X 10"	4'-0" X 10"	4'-0" X 10"	CHANDELIERS - 2@48"
Dishwasher	Width	24"	24"	24"	24"	24"
Dryer Receptacle	PHOTO					NONE
Garbage Disposal	Yes / No	YES	YES	YES	YES	YES
Ice Maker	Yes / No	YES	YES	YES	YES	YES
Medicine Cabinet	Width / Height	16"W X 20"H	16"W X 20"H	16"W X 20"H	16"W X 20"H	NONE
Range Receptacle	Type	4-PRONG	4-PRONG	4-PRONG	4-PRONG	NONE
Vents/Registers	Width / Length	12"W X 8"H 15"W X 6"H	7"W X 6"H 9"W X 6"H 10"W X 8"H 11"W X 8"H 13"W X 8"H	9"W X 6"H 10"W X 8"H 11"W X 8"H 13"W X 8"H	9"W X 6"H 10"W X 8"H 11"W X 8"H 13"W X 8"H	9"W X 6"H 10"W X 8"H 11"W X 8"H 13"W X 8"H
Thermostat	PHOTO					
Toilet Bowl	Round or Elongated	ELONGATED	ELONGATED	ELONGATED	ELONGATED	ELONGATED
Towel Bar	Length	24"	24"	24"	24"	NONE
Vanity Mirror	Width / Height	45"W X 48"H	45"W X 48"H	45"W X 48"H	45"W X 48"H	22"W X 36"H
Vanity Sink	Oval or Round/Dim	ROUND - 19"DIA	ROUND - 19"DIA	ROUND - 19"DIA	ROUND - 19"DIA	OVAL GRANITE 1-PC
Viewer/Knocker	PHOTO					

Window Schedule

Window	Width	Height	Sill Ht.	Header Ht.
W1	3'-0"	5'-10"	1'-0"	6'-10"
W2	3'-0"	6'-10"	0'-0"	6'-10"
W3	5'-11"	5'-10"	1'-0"	6'-10"

(DOOR SCHEDULE SIZES LISTED ON FLOOR PLANS)

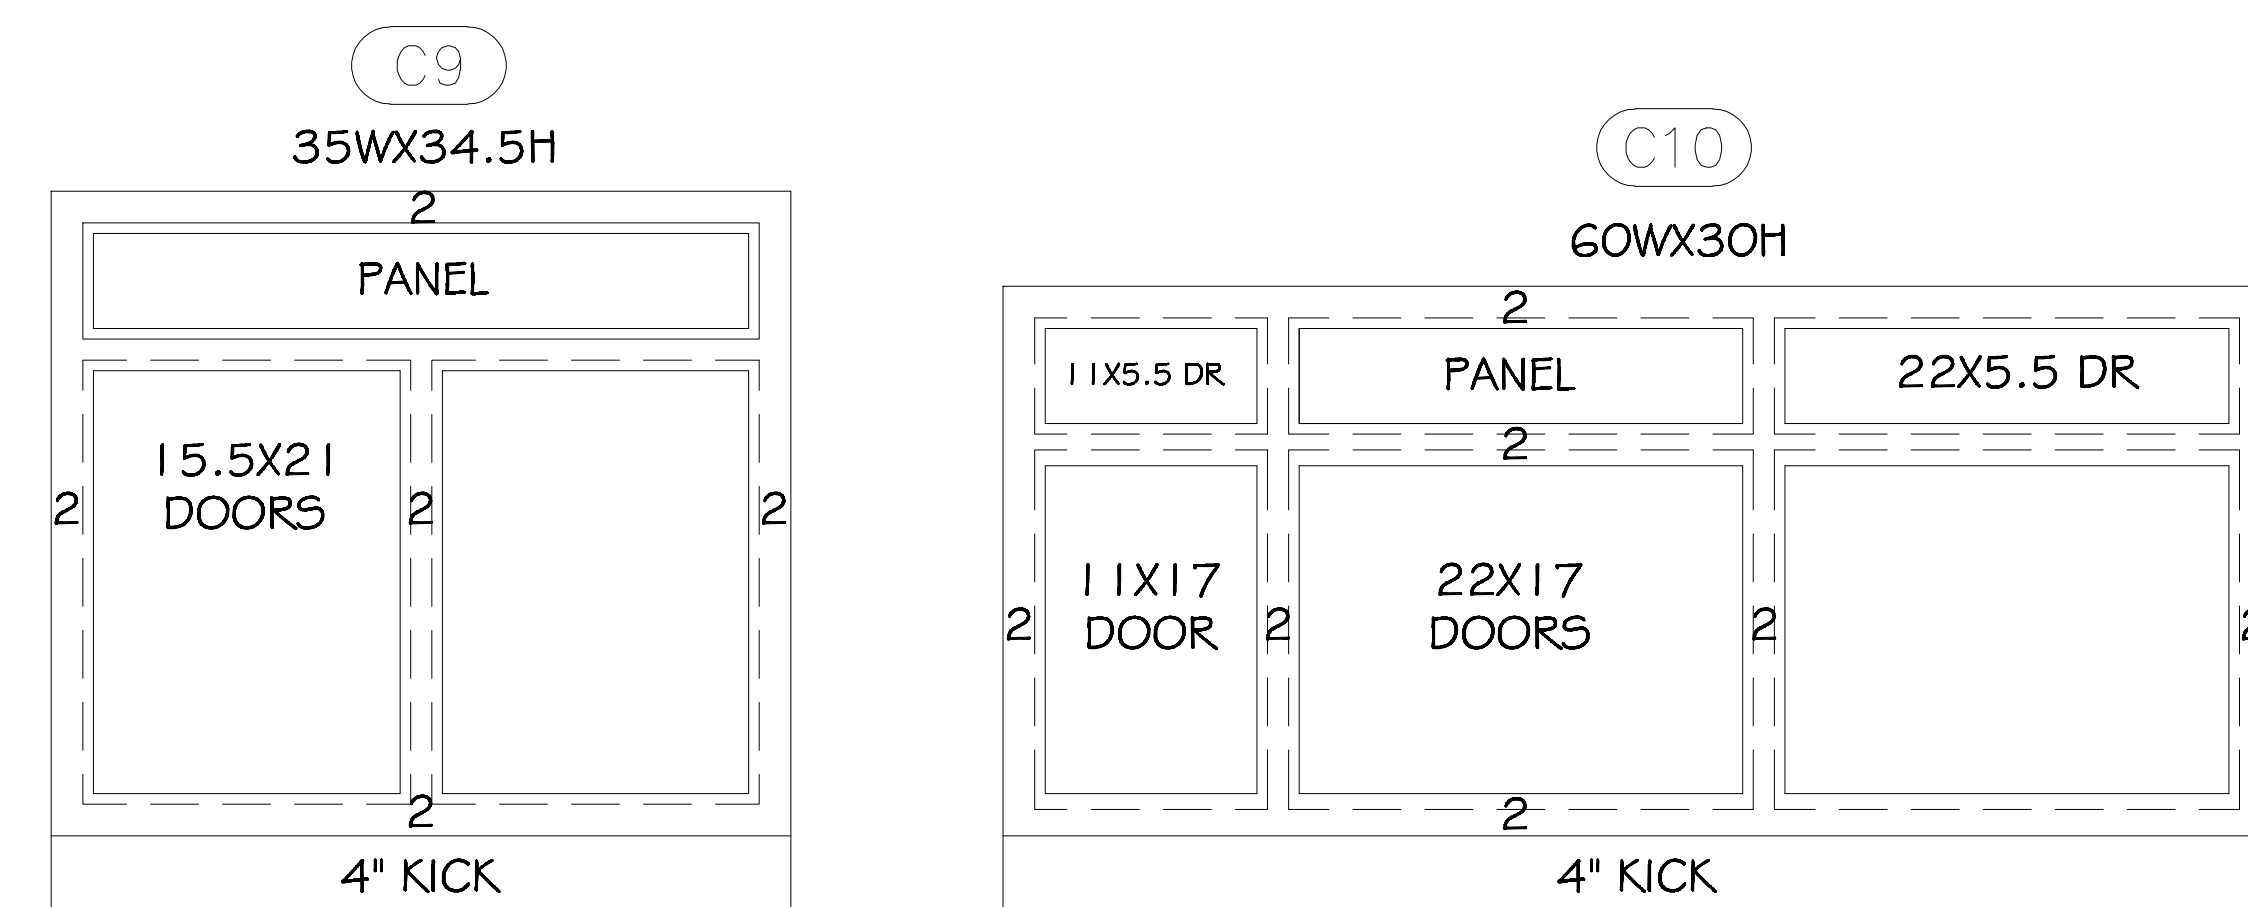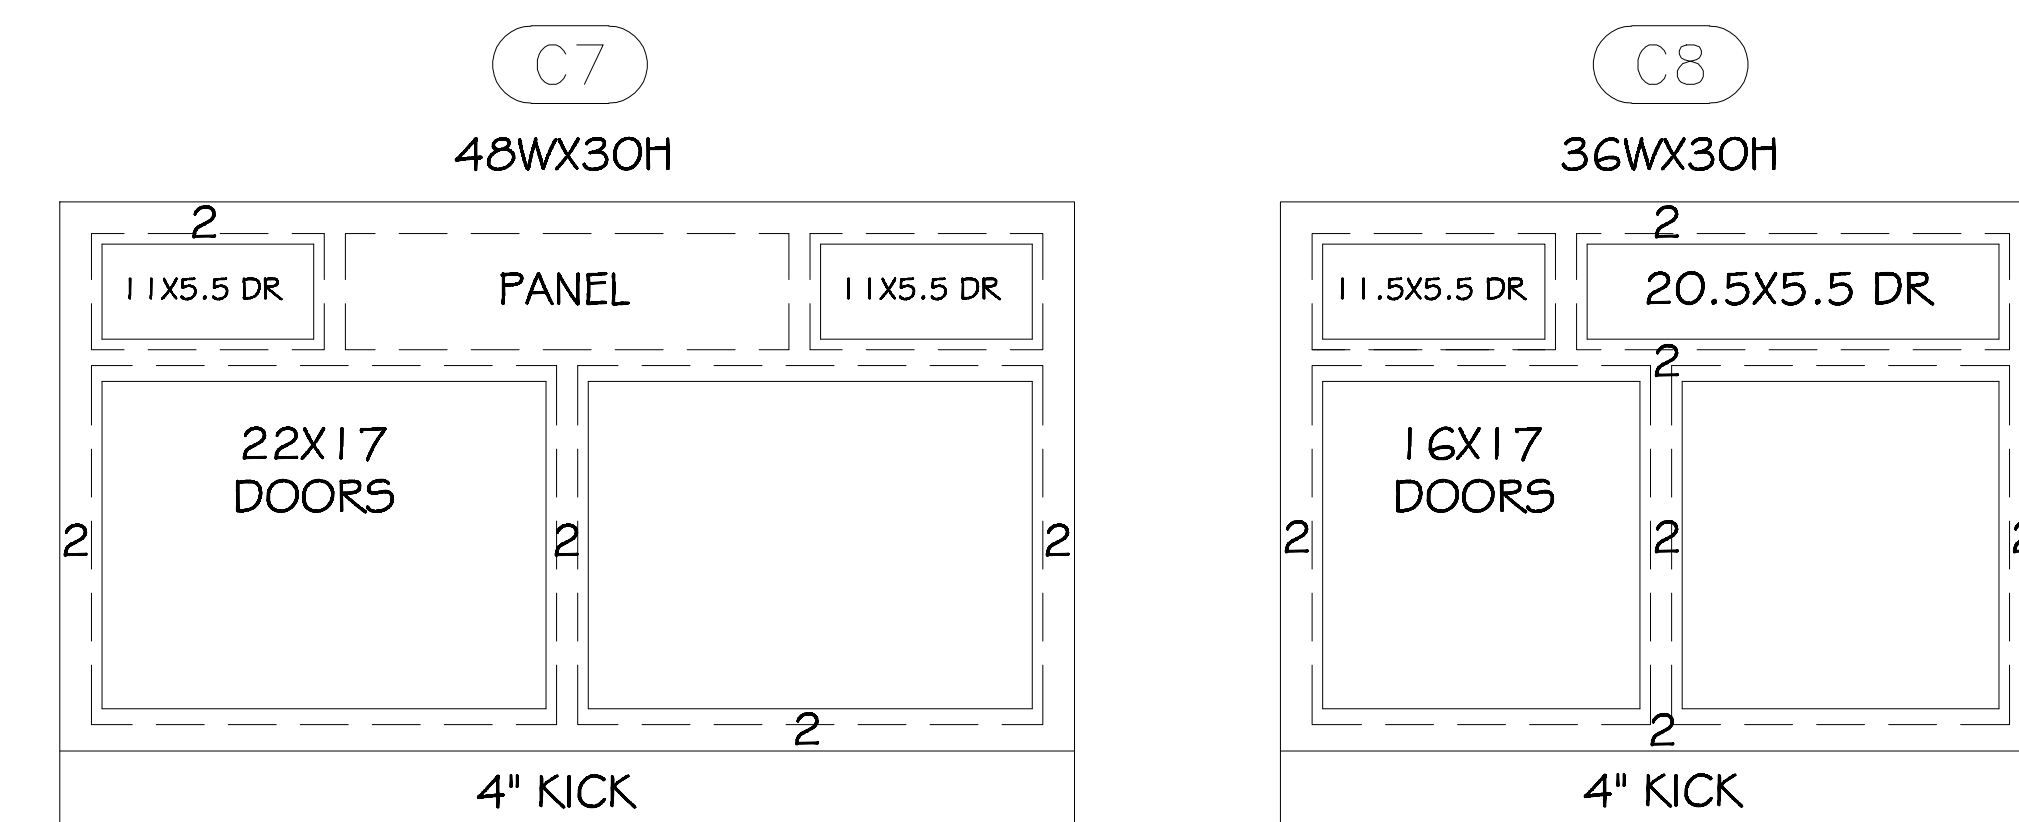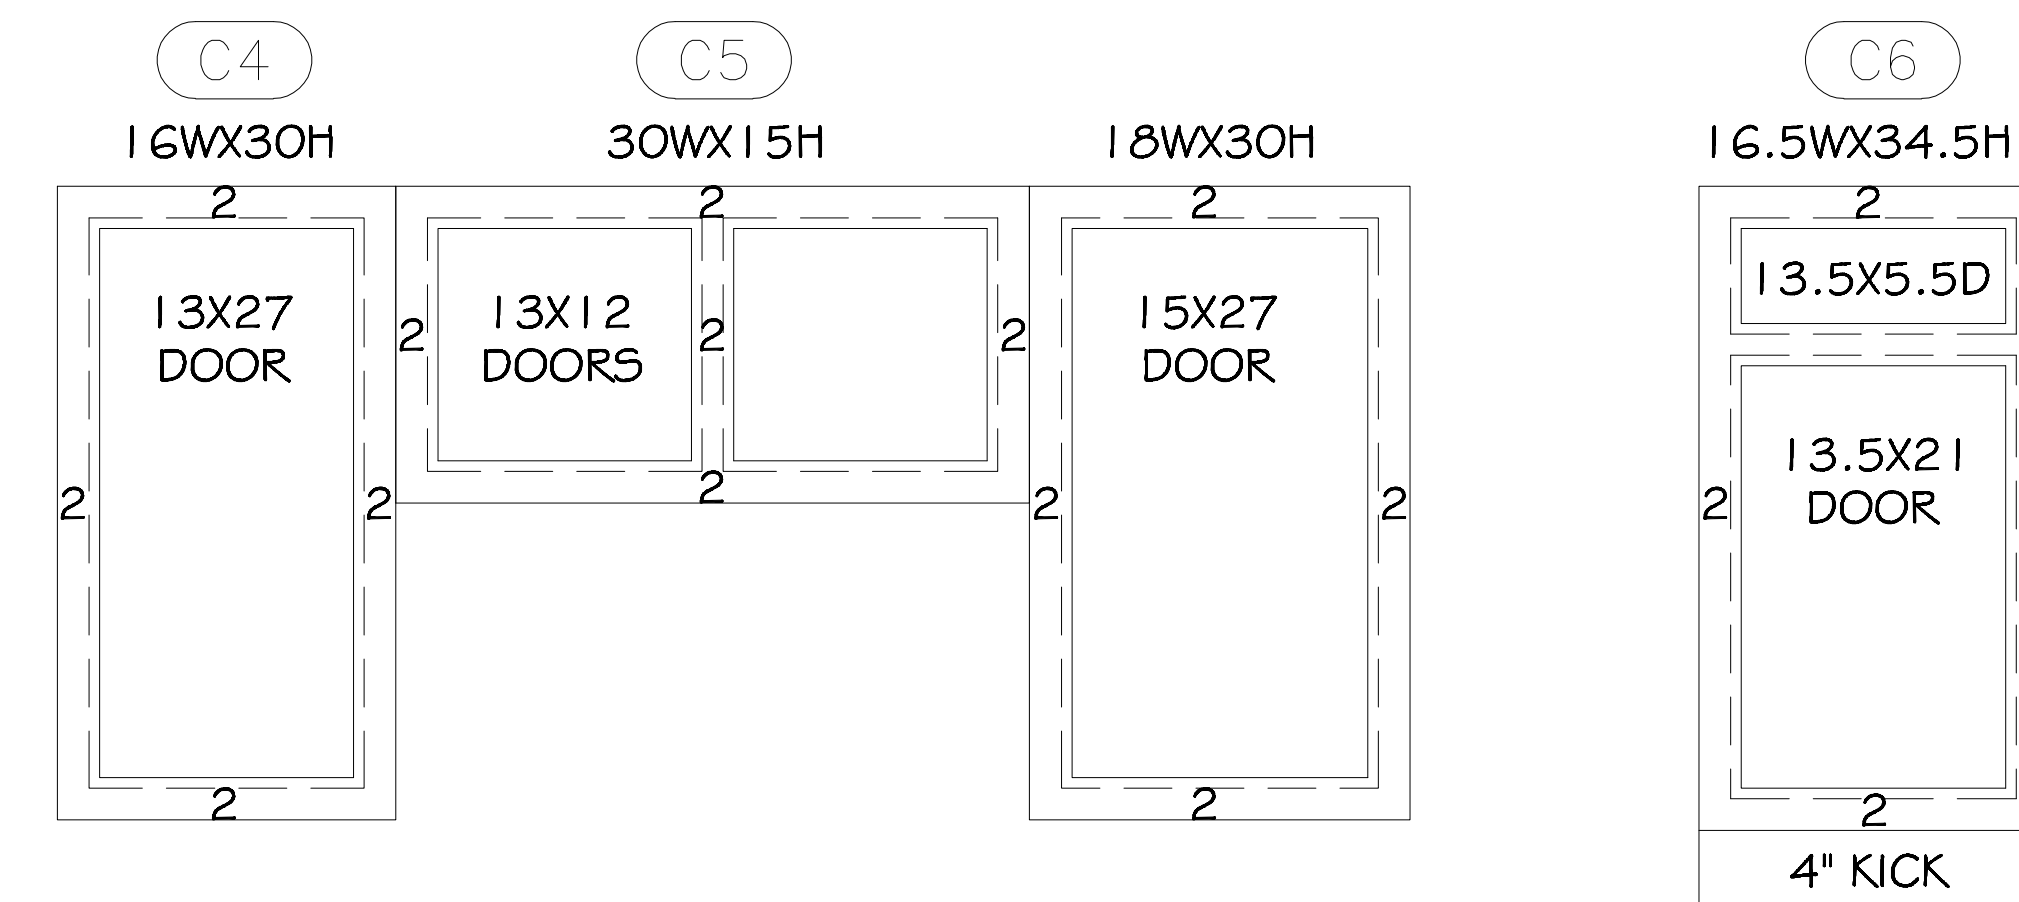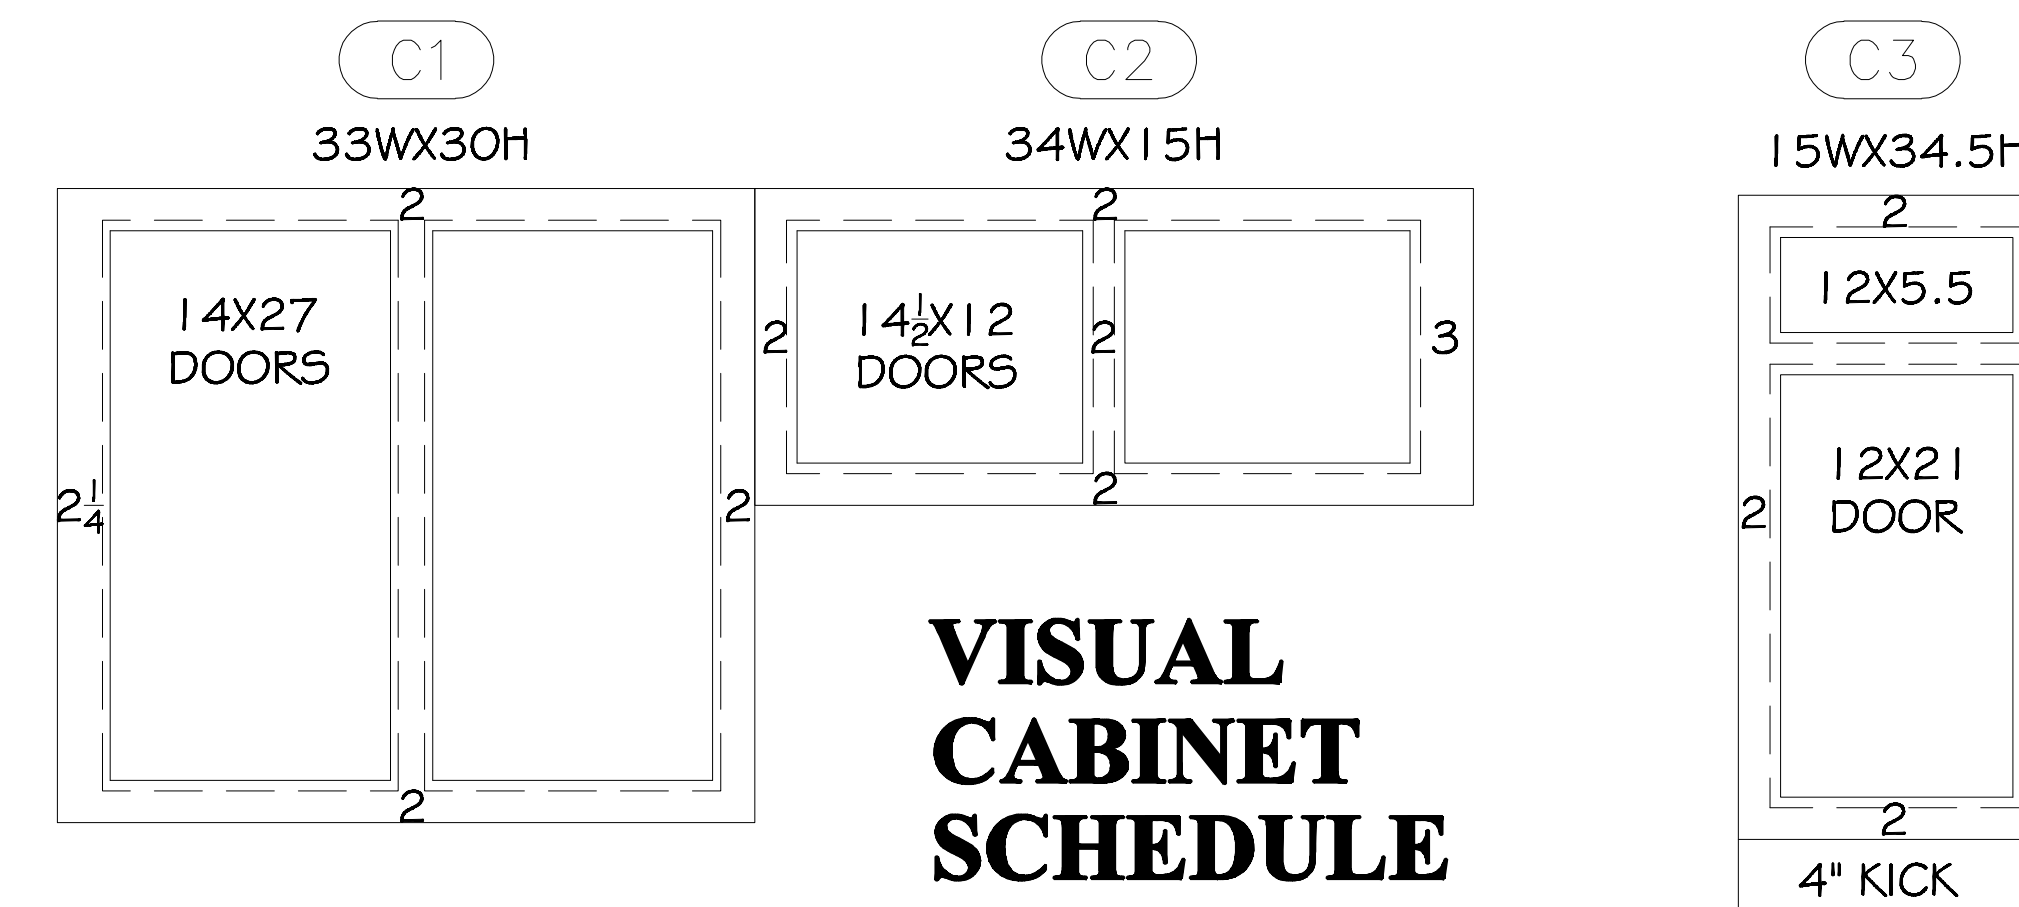

A detailed site plan of a swimming pool area. The plan shows a large rectangular 'IN-GROUND POOL' in the center. Above it is a 'CONCRETE POOL PATIO'. To the left of the pool is another 'CONCRETE POOL PATIO'. Below the pool is a 'CONCRETE POOL PATIO' and a circular 'MINI-POOL'. To the right of the pool is a 'CONCRETE POOL PATIO'. At the bottom right is a 'POOL EQUIPMENT AREA'. The entire pool area is enclosed by a 'METAL FENCE'. At the top, there is an 'ELEVATED PLANTING AREA' and 'STONE WALL' on either side. At the bottom, there is a 'GATE'.

ELEVATED PLANTING AREA

STONE WALL

STONE WALL

CONCRETE POOL PATIO

CONCRETE POOL PATIO

IN-GROUND POOL

CONCRETE POOL PATIO

MINI-POOL

CONCRETE POOL PATIO

POOL EQUIPMENT AREA

METAL FENCE

METAL FENCE

METAL FENCE

METAL FENCE

GATE

A detailed site plan for the Cordova Clubhouse and pool area. The plan shows a large rectangular pool area with an 'IN-GROUND POOL' in the center. Surrounding the pool are 'CONCRETE POOL PATIO' areas. To the right of the pool area is a 'LOCKER ROOMS AND SHOWER/ RESTROOM AREA'. Further right is a 'COMMON AREA' and a 'RAQUETBALL COURT'. In the foreground, there is a large 'CLUBHOUSE' building. The plan also includes 'FITNESS CENTER' and 'PLANTING AREA' labels. A 'GATE' is indicated at the top right. The address '8920 WALNUT GROVE ROAD CORDOVA, TN 38018' is printed in the center of the clubhouse area. The entire pool area is enclosed by a 'METAL FENCE'.

METAL FENCE

METAL FENCE

GATE

CONCRETE POOL PATIO

CONCRETE POOL PATIO

IN-GROUND POOL

CONCRETE POOL PATIO

LOCKER ROOMS AND SHOWER/ RESTROOM AREA

COMMON AREA

RAQUETBALL COURT

FITNESS CENTER

PLANTING AREA


PLANTING AREA

PLANTING AREA


8920 WALNUT GROVE ROAD
CORDOVA, TN 38018
CLUBHOUSE




01		
No.	ISSUES REVISIONS	DATE
		SHEET TITLE
SITE PLANS		
H/L		PROJECT MANAGER
H/L		PROJECT DIRECTOR
012317-1		PROJECT NUMBER
1/8"=1'-0"		SCALE
BB		DRAWN BY
		SHEET NUMBER
AB-7		

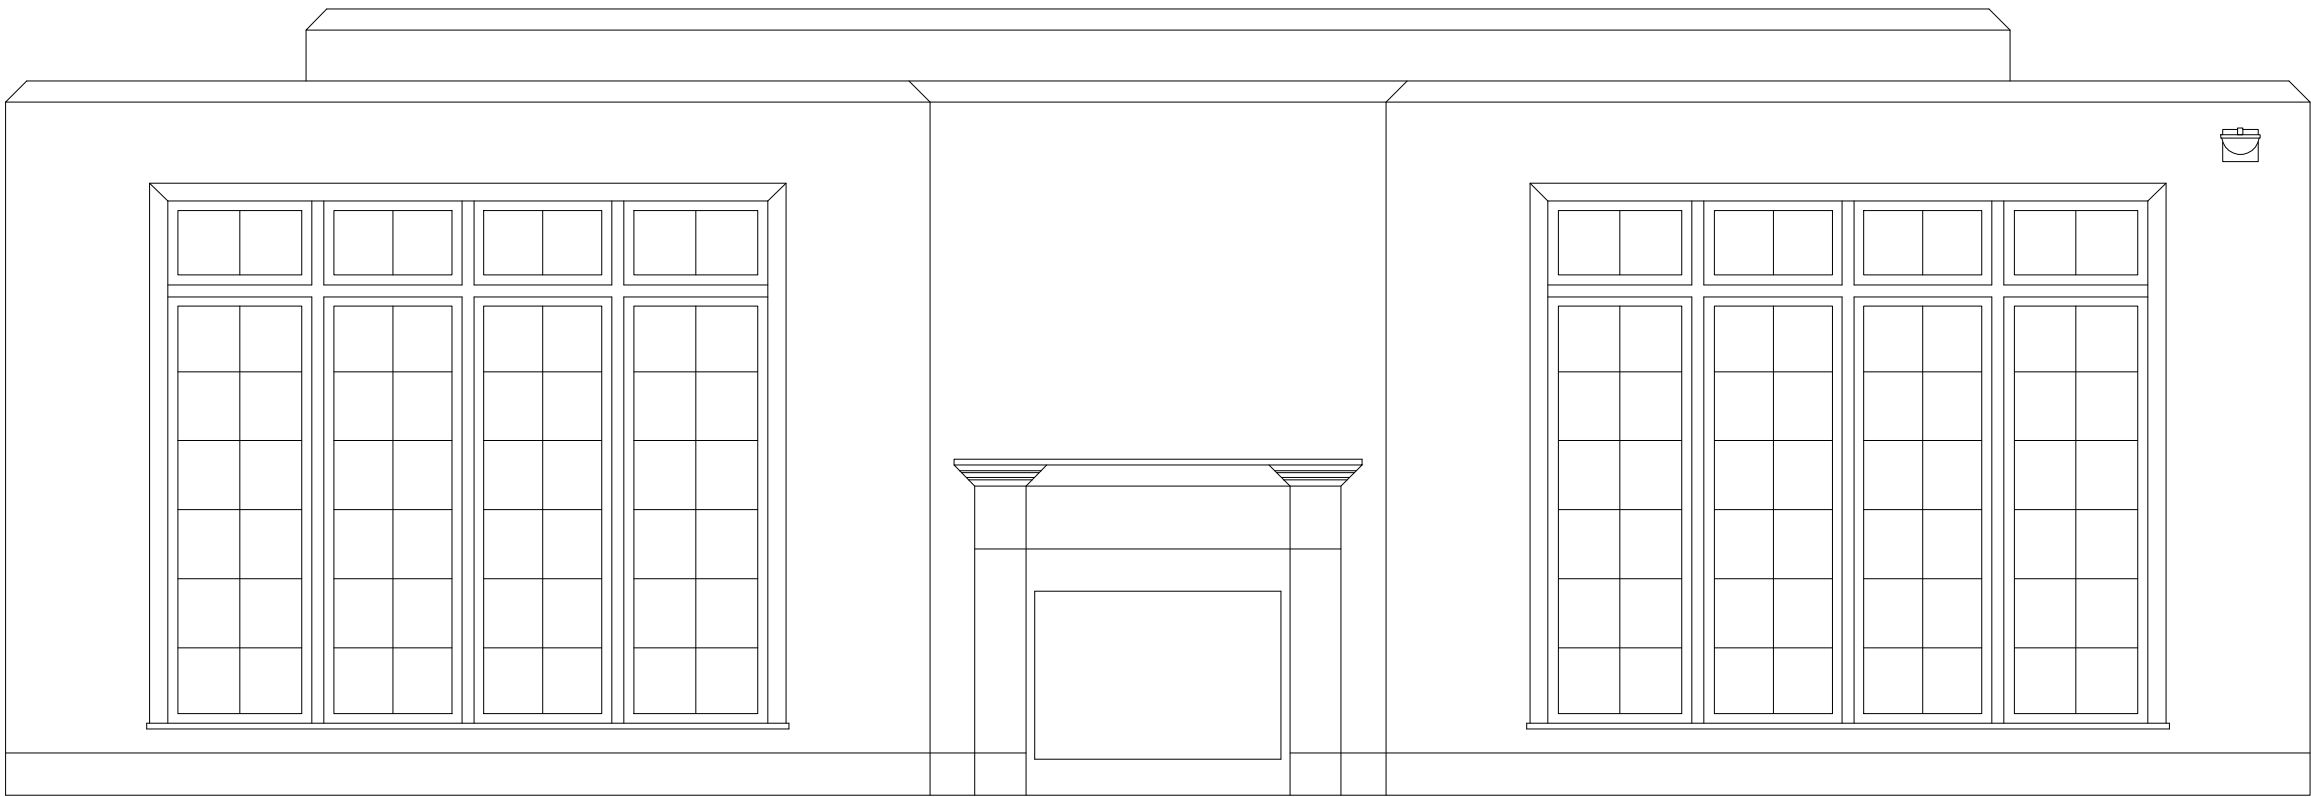


3-A
AB-8

 

2-A
AB-8

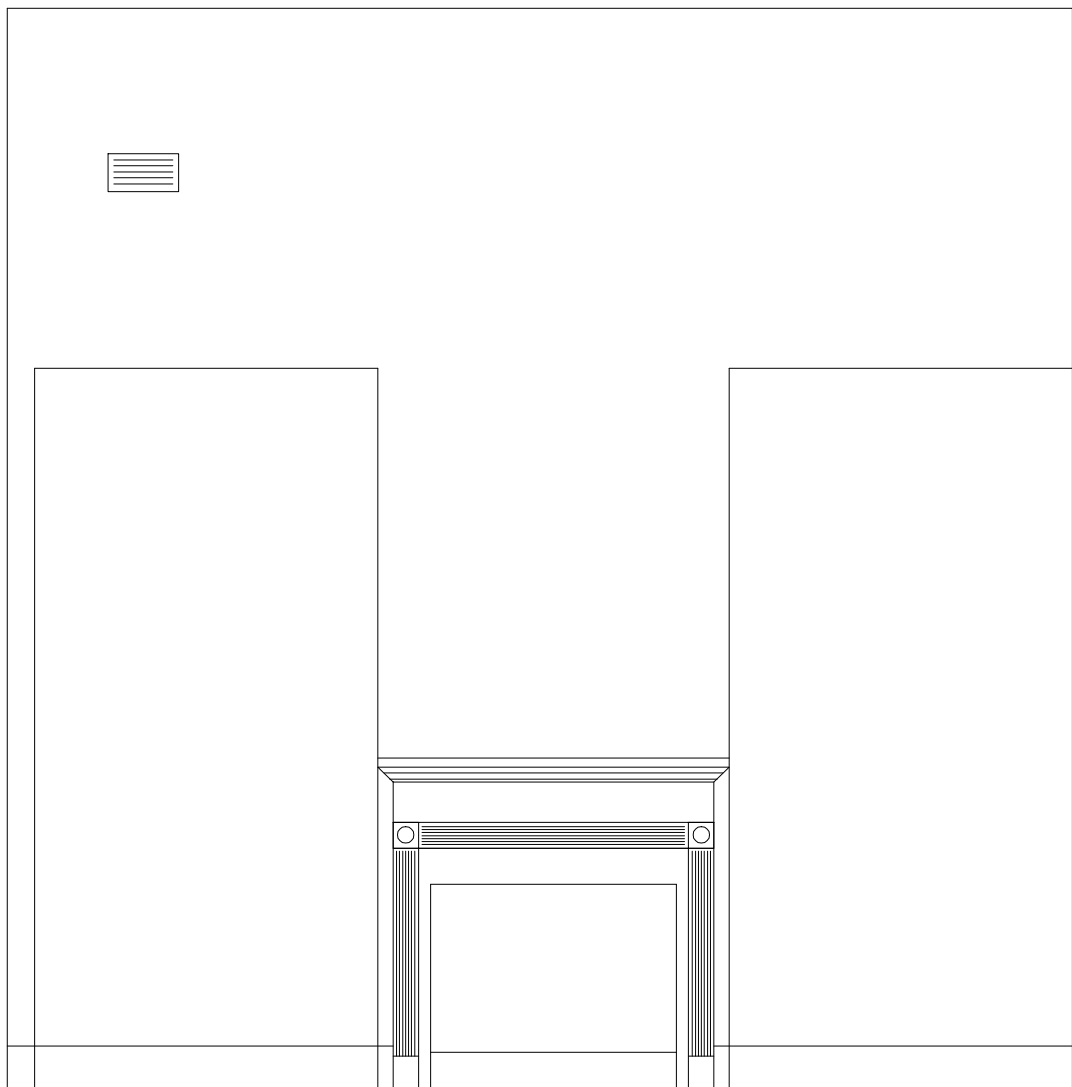

1-A
AB-8

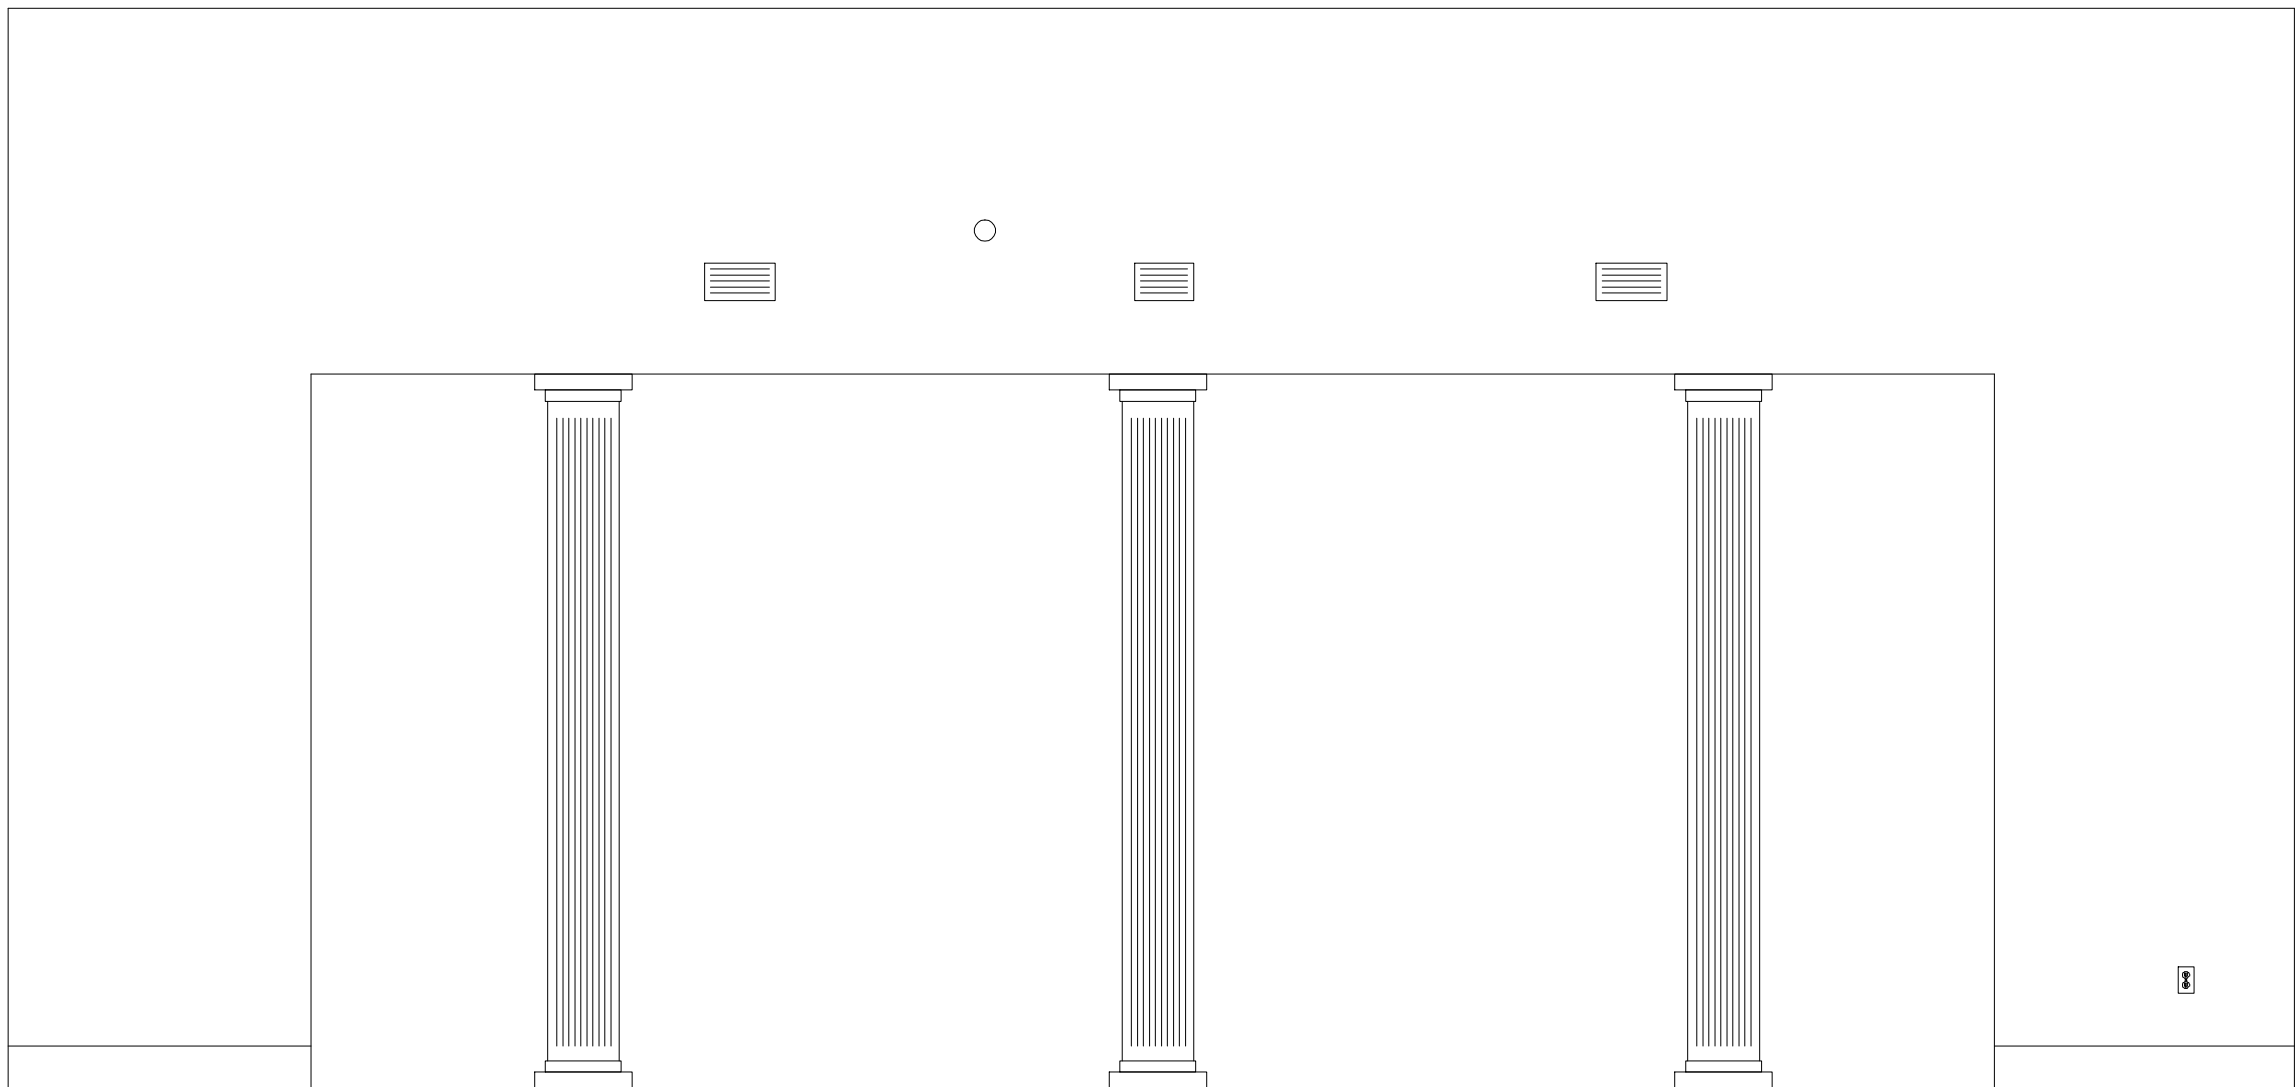

1-B
AB-8

ARCHITECTURAL AS BUILT
Walnut Hill Apartments
Cordova, TN 38018

01		
NO.	ISSUES REVISIONS	DATE

	SHEET TITLE
	CLUBHOUSE ELEVATIONS
HL	PROJECT MANAGER
HL	PROJECT DIRECTOR
012317-1	PROJECT NUMBER
3/8"=1'-0"	SCALE
BB	DRAWN BY
	SHEET NUMBER